


- ELECTRICAL LEGEND NOTES (SHEET SE-1.1 ONLY):**
- DISCONNECT SWITCH PROVIDED WITH MONUMENT/PYLON SIGN.
 - PROVIDE 1 - 4" C. (WITH PULLWIRE) FROM TELEPHONE BACKBOARD TO PROPERTY LINE. COORDINATE EXACT TERMINATION LOCATION AND INSTALLATION REQUIREMENTS WITH LOCAL TELEPHONE COMPANY.
 - PROVIDE 2#6 & 1#6G. - 3/4" C. THROUGHOUT CIRCUIT.
 - PROVIDE 2#10 & 1#10G. - 1/2" C. THROUGHOUT CIRCUIT.
 - PROVIDE 2#6 & 1#6G. - 3/4" C. THROUGHOUT CIRCUIT.
 - 208Y/120V POWER COMPANY POLE MOUNTED TRANSFORMER.


LIGHTING FIXTURE SCHEDULE

REFER TO ELECTRICAL SPECIFICATIONS FOR ADDITIONAL REQUIREMENTS WHICH MAY NOT NECESSARILY BE REFLECTED IN CATALOG NUMBER AND/OR DESCRIPTION IN THIS SCHEDULE.					
MARK	DESCRIPTION	MOUNTING	VOLT	LAMPS	REMARKS
A	(1) MCGRAW #GMA-91-1-2-208V-3V-MA1005-AP-LL-FF WITH #SSS-6M-30-MI-AP 30'-0" POLE ARM MOUNT SINGLE LUMINAIRE.	POLE MOUNTED, SEE DETAIL, THIS SHEET.	208	1-1000W-SUPER METAL HALIDE PER LUMINAIRE	PROVIDE GREY FINISH. PROVIDE POLE WIND RATING FOR AREA INSTALLED.
A2	(2) MCGRAW #GMA-91-1-2-208V-3V-MA1005-AP-LL-FF WITH ROTATED OPTICS WITH #SSS-6M-30-MI-AP 30'-0" POLE ARM MOUNT DOUBLE LUMINAIRES 180 DEGREES APART.	POLE MOUNTED, SEE DETAIL, THIS SHEET.	208	1-1000W-SUPER METAL HALIDE PER LUMINAIRE	PROVIDE GREY FINISH. PROVIDE POLE WIND RATING FOR AREA INSTALLED.
WL	LUMARK #MHWL-250-MT BUILDING MOUNTED.	SURFACE MOUNTED, AT 18'-0" A.F.F.	208	1-250W-SUPER METAL HALIDE	PROVIDE GREY FINISH.
WP	LUMARK #MHWL-400-MT-LL BUILDING MOUNTED.	SURFACE MOUNTED, AT 18'-0" A.F.F.	208	1-400W-SUPER METAL HALIDE	PROVIDE GREY FINISH.


NOTE: ALL FIXTURES SHALL BE PURCHASED THROUGH INNERSOURCE (CONTACT CAROL MARKUS 610-832-1490)

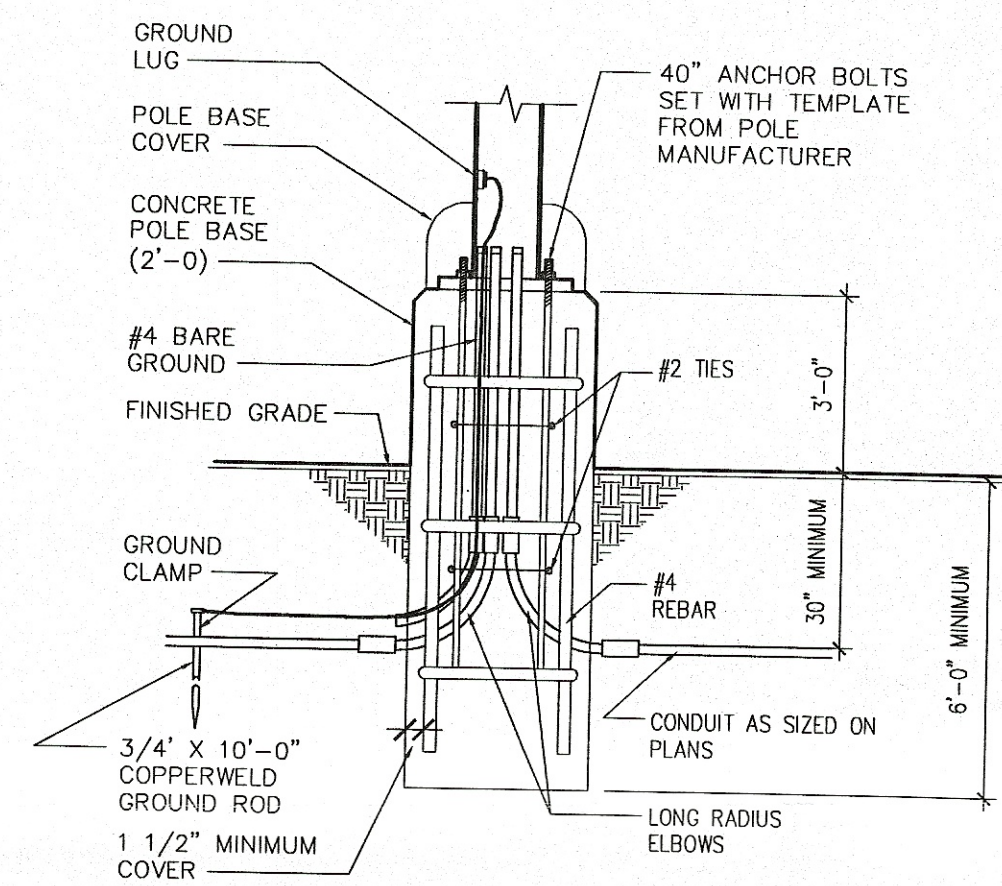


2 SITE LIGHTING POLE BASE DETAIL
SE-1.1 SCALE: NOT TO SCALE

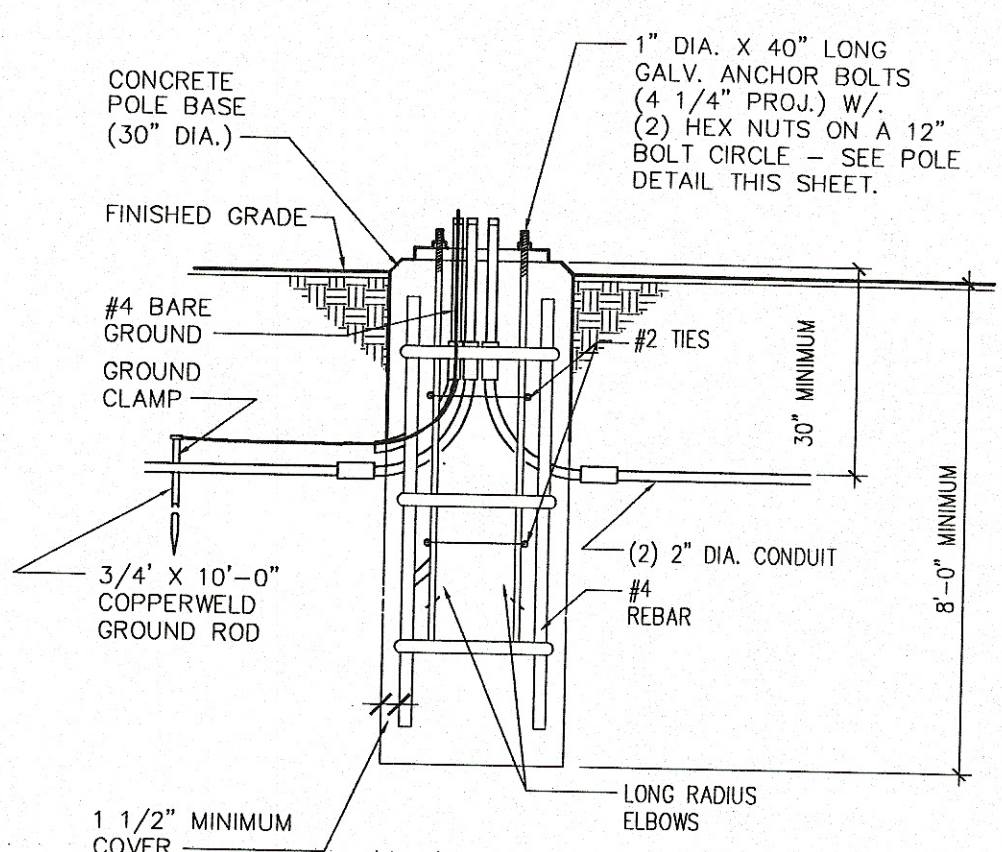

3 STREET LIGHTING POLE BASE DETAIL
SE-1.1 SCALE: NOT TO SCALE (BASE & CONDUIT BY E.C.)

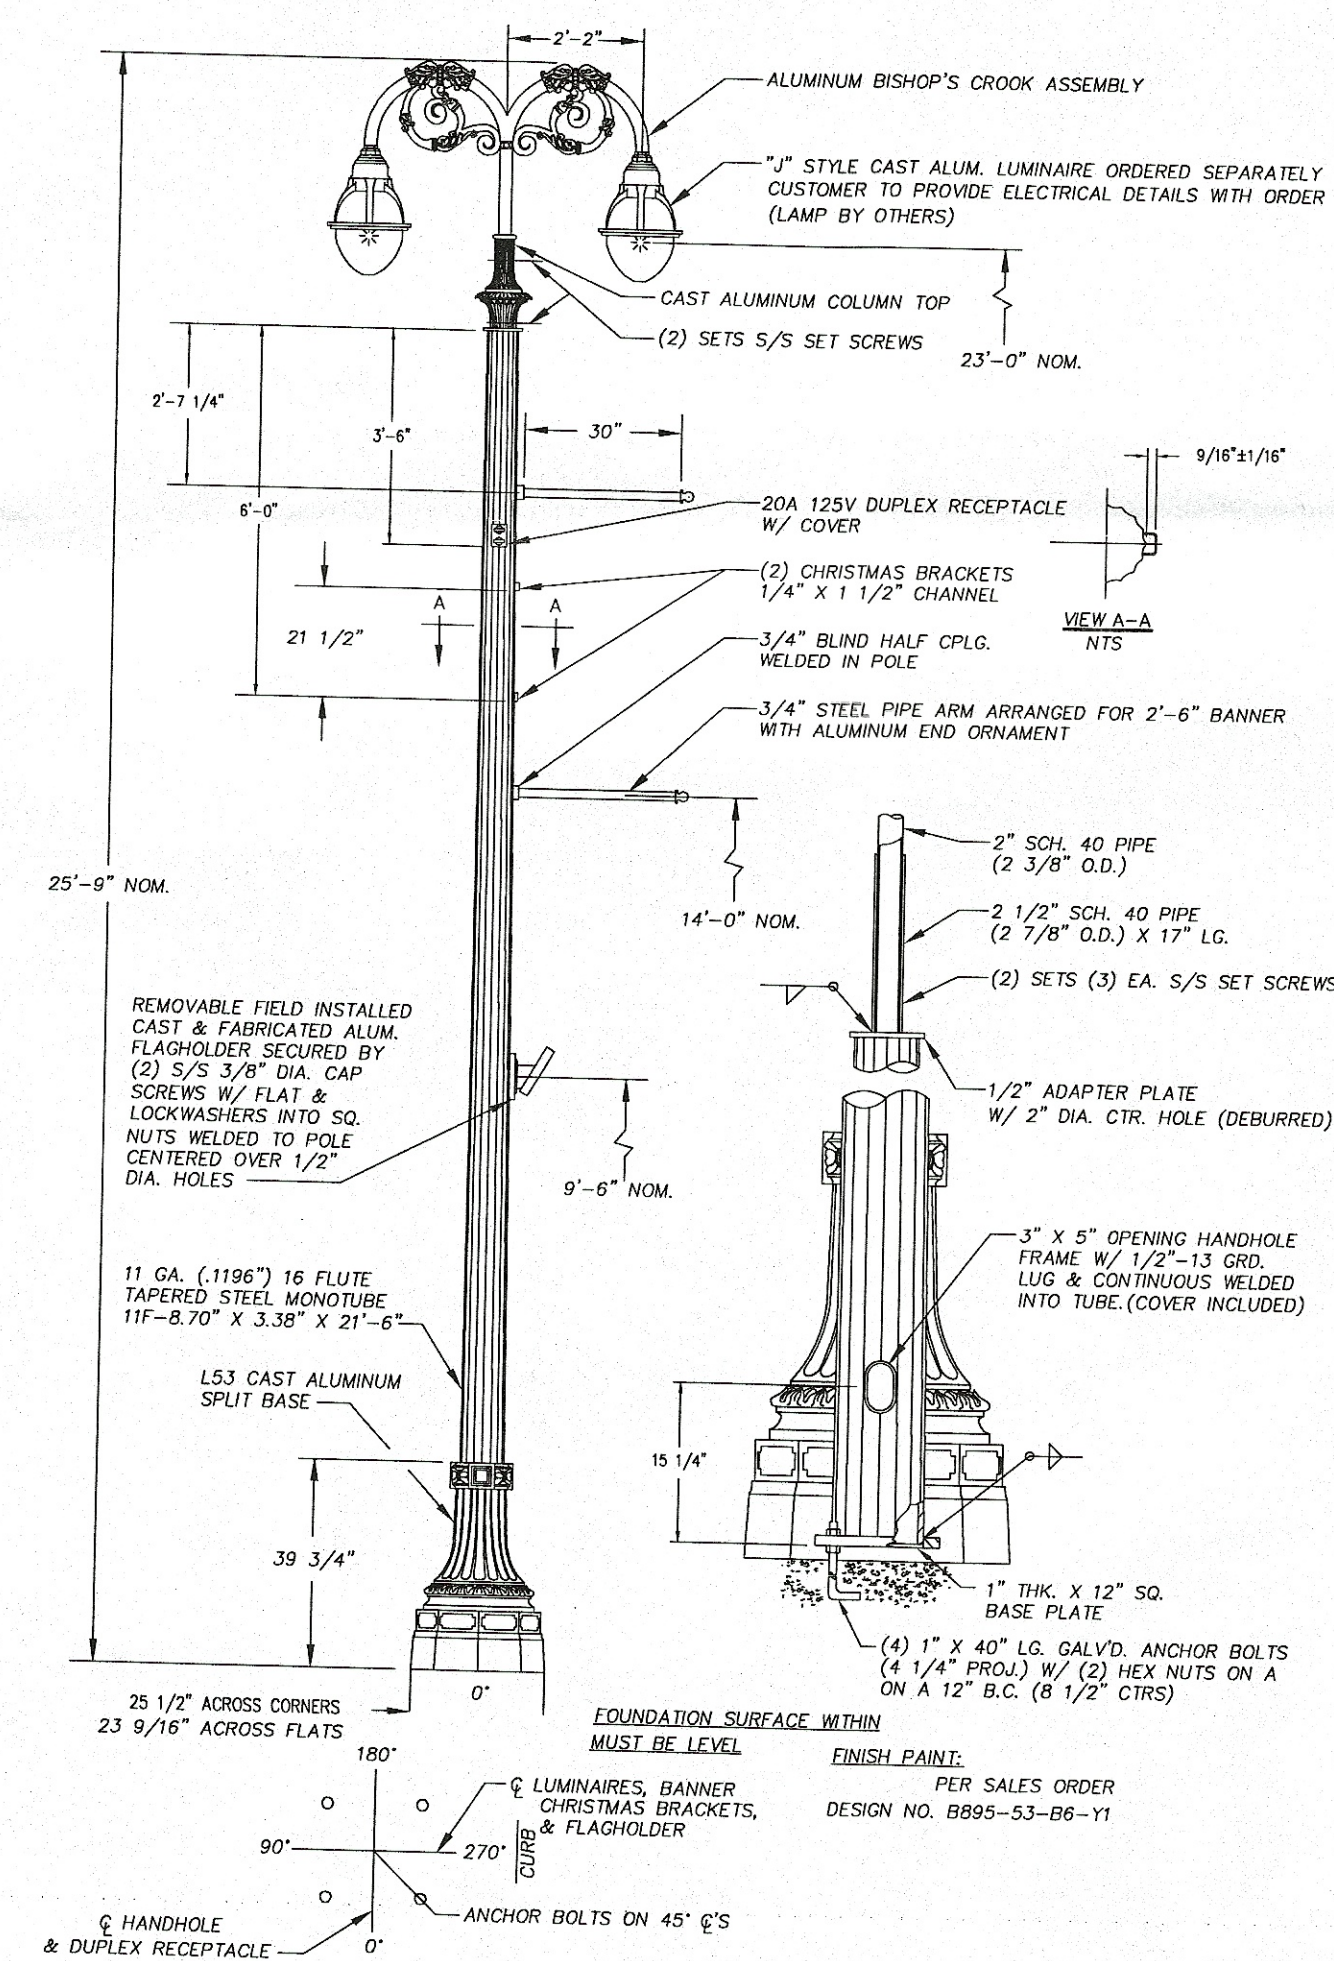

4 STREET LIGHT POLE DETAIL (POLE BY OTHERS - N.I.C.)
SE-1.1 SCALE: NOT TO SCALE

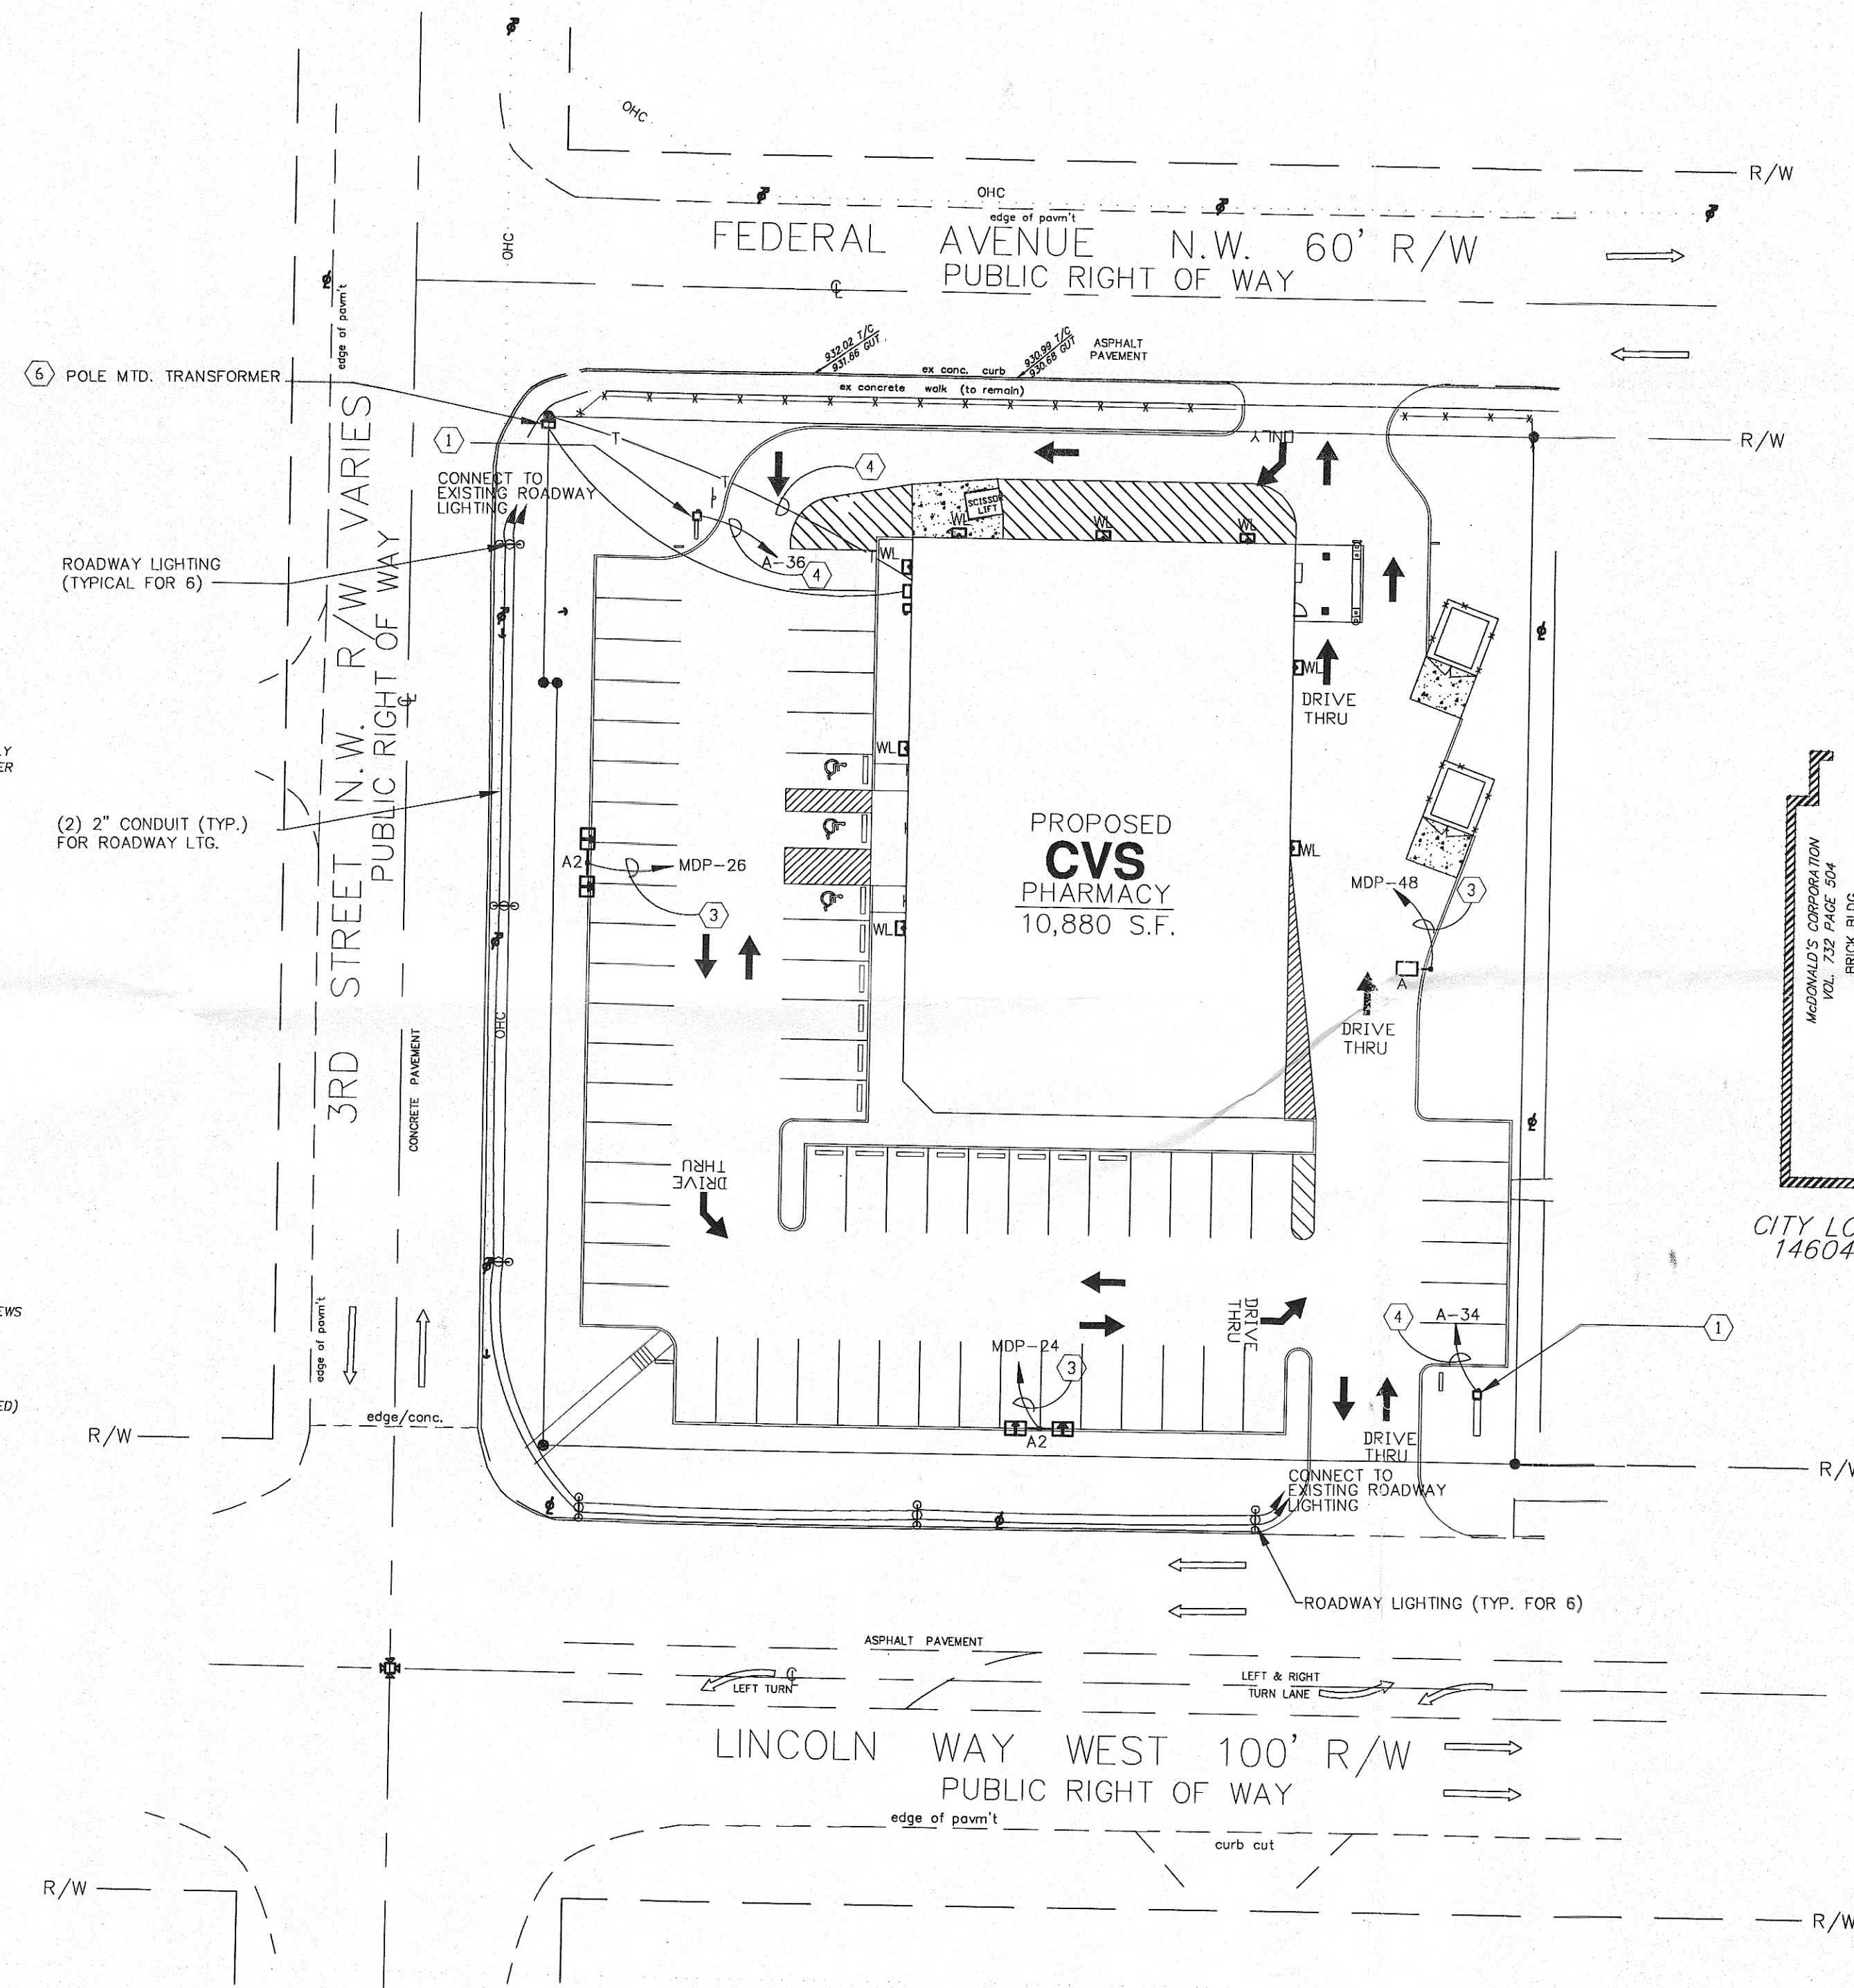

1 SITE PLAN - ELECTRICAL
SE-1.1 SCALE: 1" = 30'-0"

F. Matthew Ray, Architect
3394 West Twelve Mile Road
Berkley, Michigan 48072
T: (248) 744-3384
F: (248) 744-3388
E: FMRAYARCH@AOL.COM

CONSULTANT:

DRAWING ALTERATION
IT IS A VIOLATION OF LAW FOR ANY PERSON, UNLESS ACTING UNDER THE DIRECTION OF A LICENSED ARCHITECT, PROFESSIONAL ENGINEER, LANDSCAPE ARCHITECT, OR LAND SURVEYOR TO ALTER ANY ITEM ON THIS DOCUMENT.
ANY LICENSEE WHO ALTERS THIS DOCUMENT IS REQUIRED BY LAW TO AFFIX HIS OR HER SEAL AND THE NOTATION "ALTERED BY" FOLLOWED BY HIS OR HER SIGNATURE AND SPECIFIC DESCRIPTION OF THE ALTERATIONS.

SEAL:

CVS/
pharmacy

STORE NUMBER: #4420
242 LINCOLN WAY WEST
MASSILLON, OH 44646

DEVELOPER:

ZAREMBA GROUP
14600 Detroit Ave., Suite 1500
Lakewood, Ohio 44107
TEL (216) 221-6600
FAX (216) 221-1031
CONTACT: Bruce Noggle

REVISIONS:

LAYOUT COORD: 0000
PLANNING MGR: MEH
DRAWING BY:
DATE: March 15, 2001
JOB NUMBER: 01007
TITLE:

SITE ELECTRICAL PLAN

SHEET NUMBER:


SE-1.1

COMMENTS:
BIDS & PERMITS

DO NOT SCALE DRAWINGS

PANELBOARD										C	SCHEDULE																		
VOLTAGE: 208Y/120 V		MAINS		MLO		MOUNTING		SURFACE		REMARKS																			
BUS SIZE: 60 A		TOTAL LOAD		7.4 KVA		FAULT DUTY		42000 A		PROVIDE ADDITIONAL GROUND BUS INSULATED FROM CAN.																			
SERVES		LTG	RCPT	LOAD (KVA)		MTR	A/C	HTG	MISC	BRKR	TRIP	P	PH	BRKR	A	B	C	P	TRIP	MISC	HTG	LOAD (KVA)		MTR	REPT	LTG	SERVES		No.
1	FRONT ENTRANCE REGISTER								0.4	20	1		●	1	20										0.5			PHARMACY REGISTER	2
3	VSAT/POS EQUIPMENT								0.5	20	1		●	1	20										0.4			ISO GND RECEPT, PHARMACY	4
5	FRONT ENTRANCE REGISTER								0.4	20	1		●	1	20					0.2						0.4		PHOTO LAB REGS /IG REC	6
7	EMS SYSTEM (1)								0.2	20	1		●	1	20					0.2								TELEPHONE SYSTEM	8
9	P.O.S. EQUIPMENT		0.2							20	1		●	1	20					0.2								ALARM SYSTEM (1)	10
11	SPARE									20	1		●	1	20					0.4								PILL COUNTER	12
13	PHARMACY RCPTS.		0.5							20	1		●	1	20										0.4			ISO GND RECEPT, PHARMACY	14
15	RCPT., PHARMACY		0.9							20	1		●	1	20										0.7			ISO GND RECEPT, PHARMACY	16
17	UPS REC PHARMACY		0.9							20	1		●	1	20					2.5	0.0	0.0	0.0	4.9	0.0			SPARE	18

ELECTRIC LOAD SUMMARY		
TOTAL CONNECTED LOAD:	564	AMPS
TOTAL N.E.C. LOAD:	547	AMPS
MAIN SERVICE SWITCH	600	AMP
MAIN SERVICE FUSE	600	AMP
MAIN SERVICE CONDUCTORS	2 SETS 4 # 350 KCMIL	
MAIN SERVICE CONDUITS	2 - 3" CONDUITS	

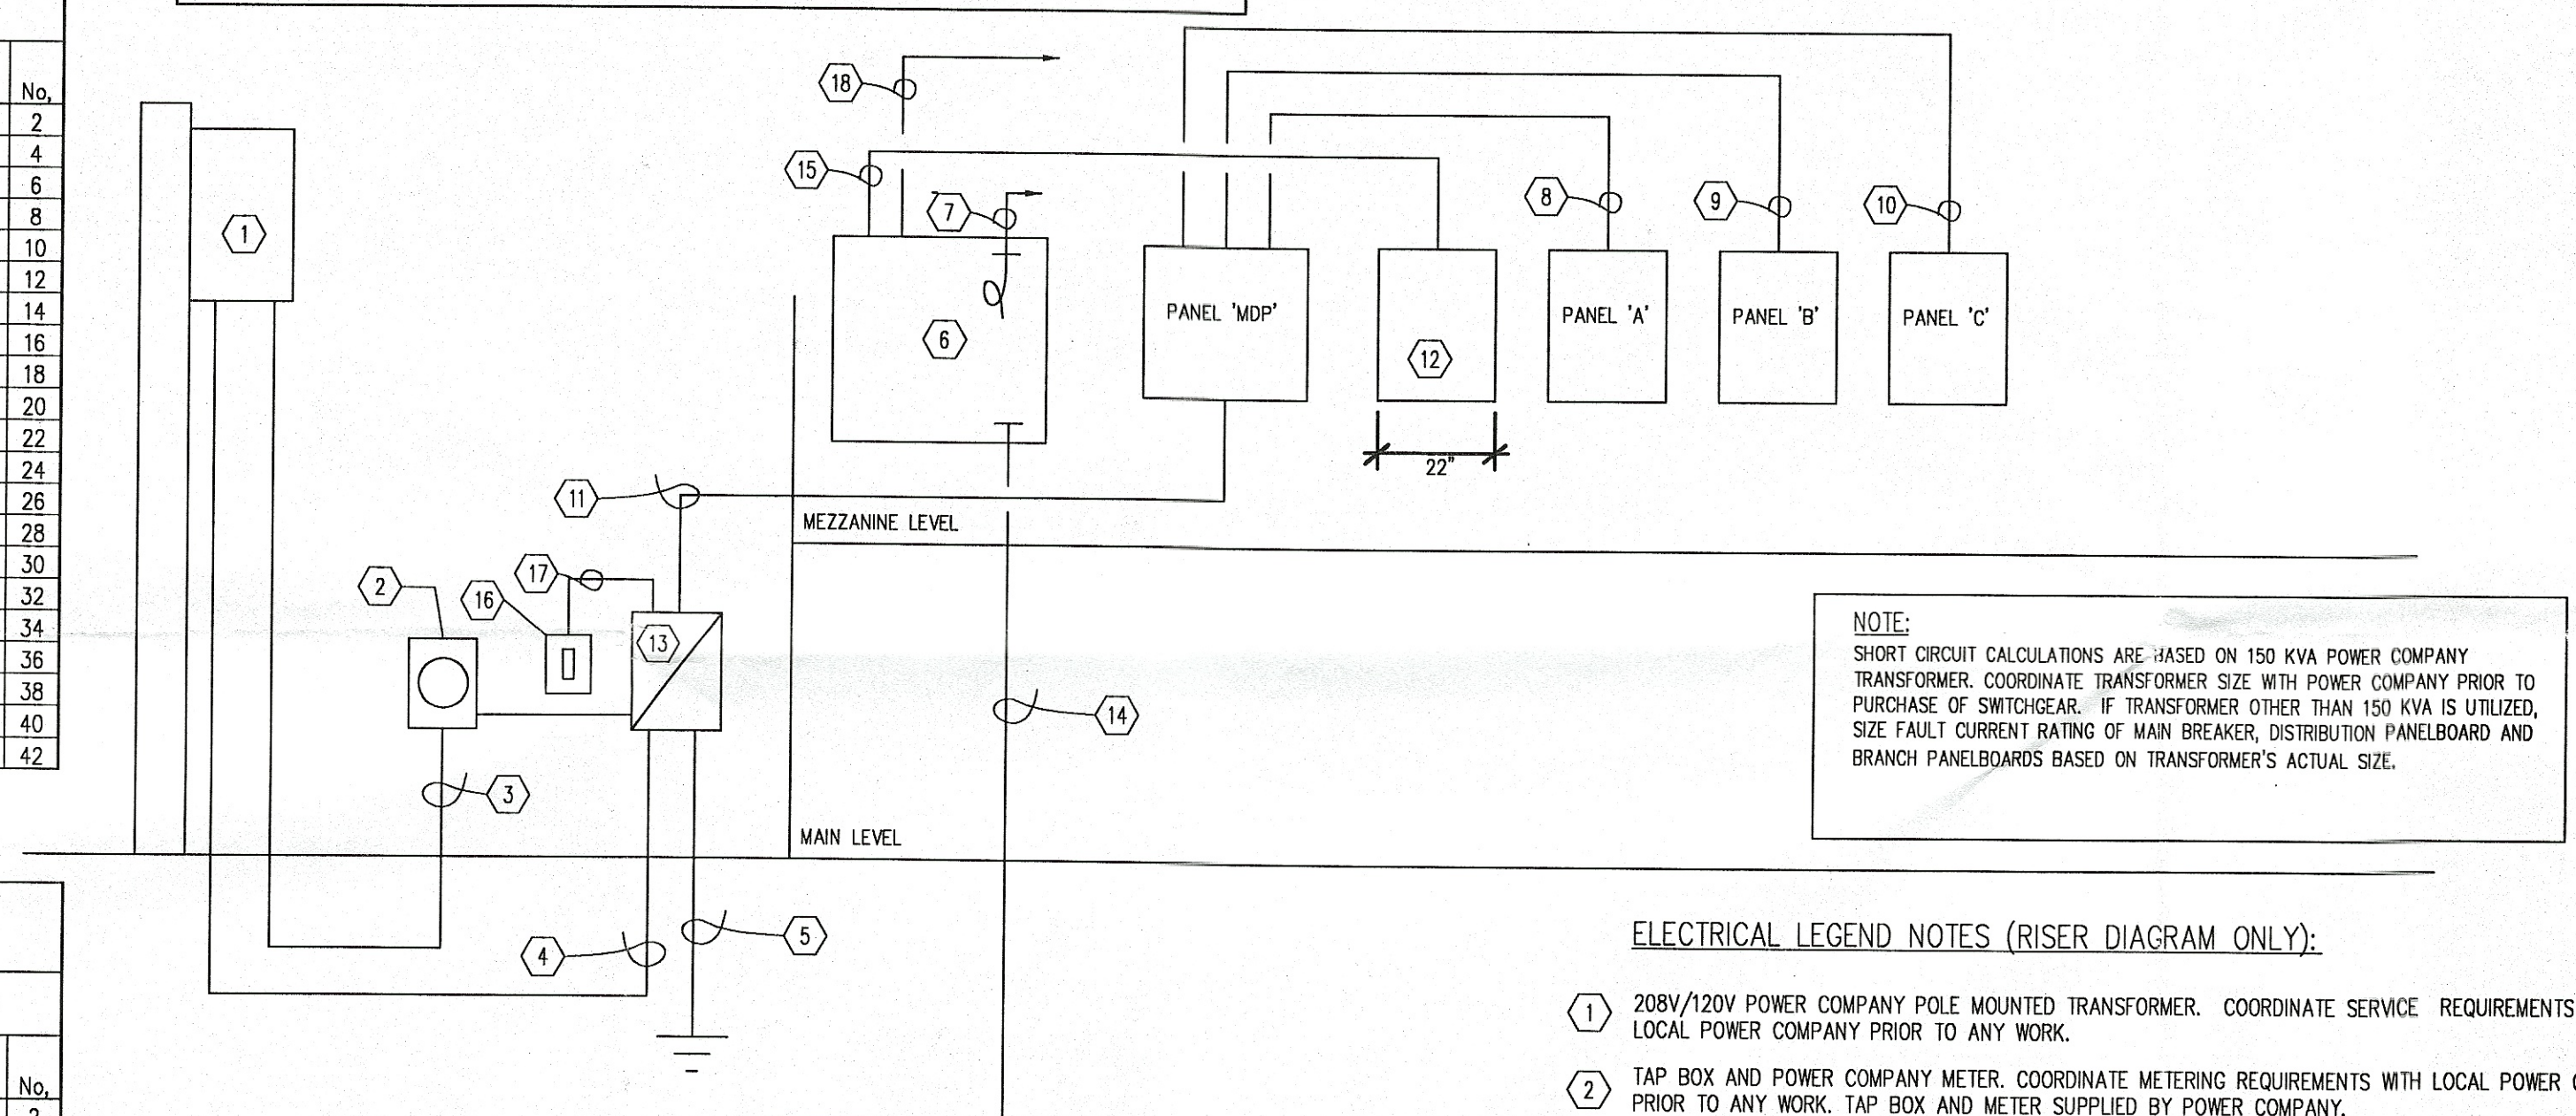

- (1) PROVIDE LOCK-ON DEVICE FOR CIRCUIT BREAKER.
- (2) PROVIDE H.A.C.R. TYPE CIRCUIT BREAKER.
- (3) FOR FULL MEZZANINE STORES ONLY

1. INSTALL AND LOAD ALL REGISTERS.
2. INSTALL AND CHECK OFFICE EQUIPMENT.
3. MOUNT SPENCER P.O.S. LOOP CASHIN IN CASH ROOM
4. IDENTIFY AND TERMINATE ALL P.O.S. WIRE.
5. INSTALL AND TEST TIME CLOCK.
6. CONNECT AND TERMINATE MODEM AND/OR V.S.A.T. LINES.
7. BUILD OFFICE COMPUTER CABINET.
8. DRILL HOLES IN OFFICE COUNTER AS NEEDED.
9. TIE UP ALL LOOSE WIRES.
10. INSTALL AND TEST PHARMACY COMPUTER EQUIPMENT.
11. CUT HOLE IN LASER PRINTER CABLE.
12. TEST AND CONNECT COMMUNICATIONS LINES TO MODEMS.
13. TERMINATE AND/OR CONNECT SATELLITE LINES.
14. MOUNT ALL TYPE 1 FACE PLATES AND LOOP ATTACHMENT BOXES UNDER THE PHARMACY AND FRONT CHECKOUTS.
15. INSTALL ALL PHONE BRACKETS.

(MDP PANEL) = $75-1\frac{1}{2}''$ H.
 $11-1\frac{1}{2}''$ D.

(PANEL A) = $43-1\frac{1}{2}''$ H.
 $5-3\frac{3}{4}''$ D.

(PANEL B) = $37-1\frac{1}{2}''$ H.
 $5-3\frac{3}{4}''$ D.

(PANEL C) = $25-1\frac{1}{2}''$ H.
 $5-3\frac{3}{4}''$ D.

NOTE:
CVS HAS A NATIONAL ACCOUNT WITH GENERAL ELECTRIC FOR EQUIPMENT DISTRIBUTION.
CONTACT PAM ANZIVINO / 1-800-244-6980


CVS/
pharmacy

DEVELOPER:


ZAREMBA GROUP
14600 Detroit Ave., Suite 1500
Lakewood, Ohio 44107
TEL (216) 221-6600
FAX (216) 221-1031
CONTACT: Bruce Noggle

AYOUT COORD:	0000
LANNING MGR.	MEH
RAWING BY:	
ATE:	March 15, 2001
OB NUMBER:	01007


ELECTRICAL SCHEDULES &
 RISER DIAGRAM
 SHEET NUMBER:
 E-2.2
 COMMENTS:
 AIDS & PERMITS
 DO NOT SCALE FROM THIS

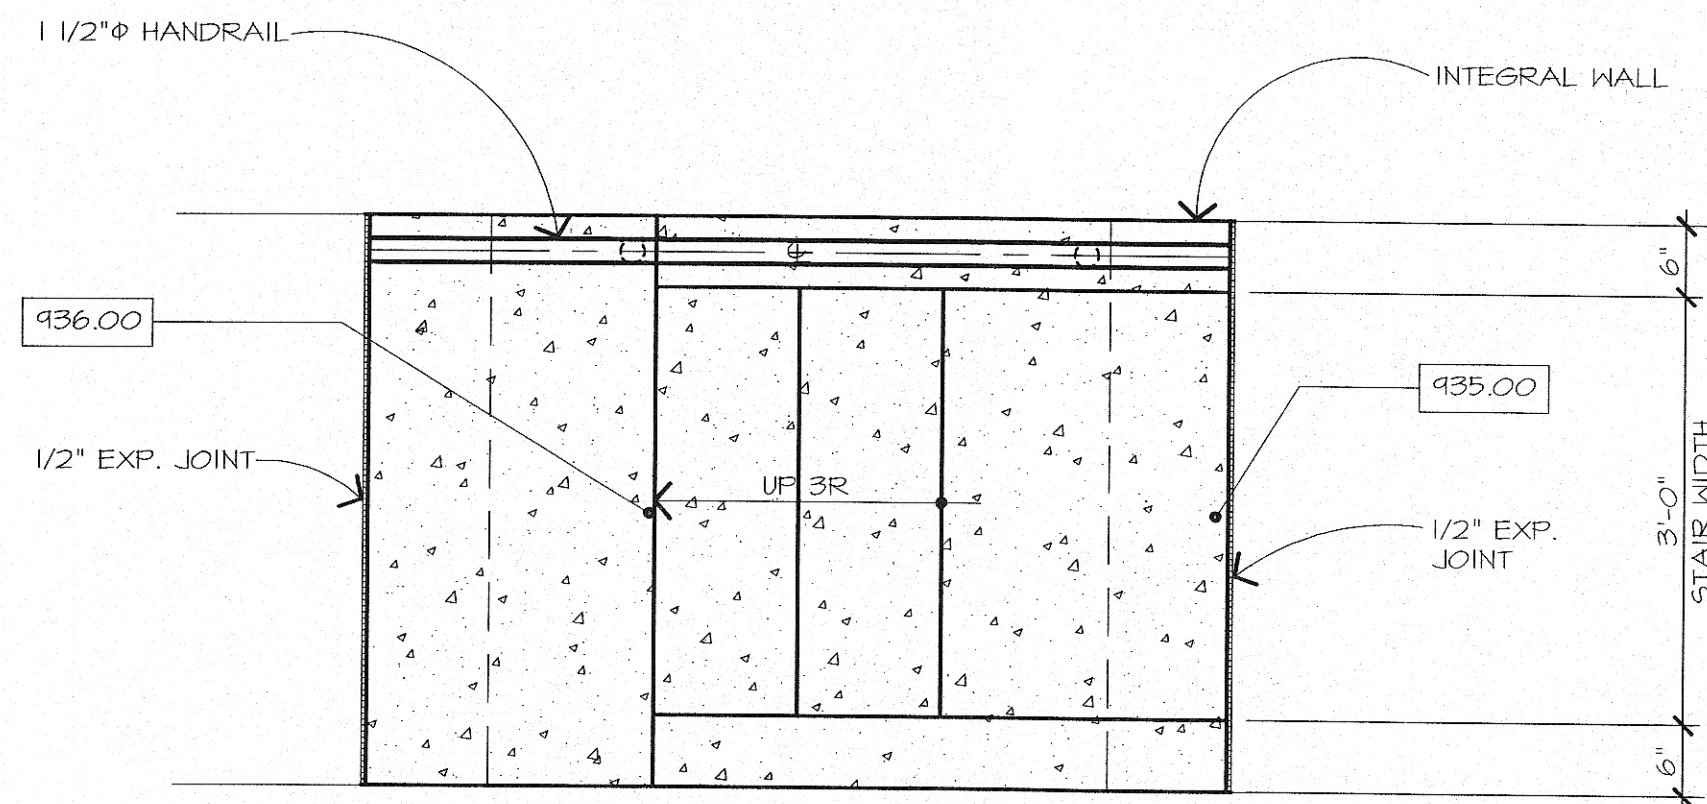


9 Plan Detail @ Concrete Stair • 3/4" = 1'-0"

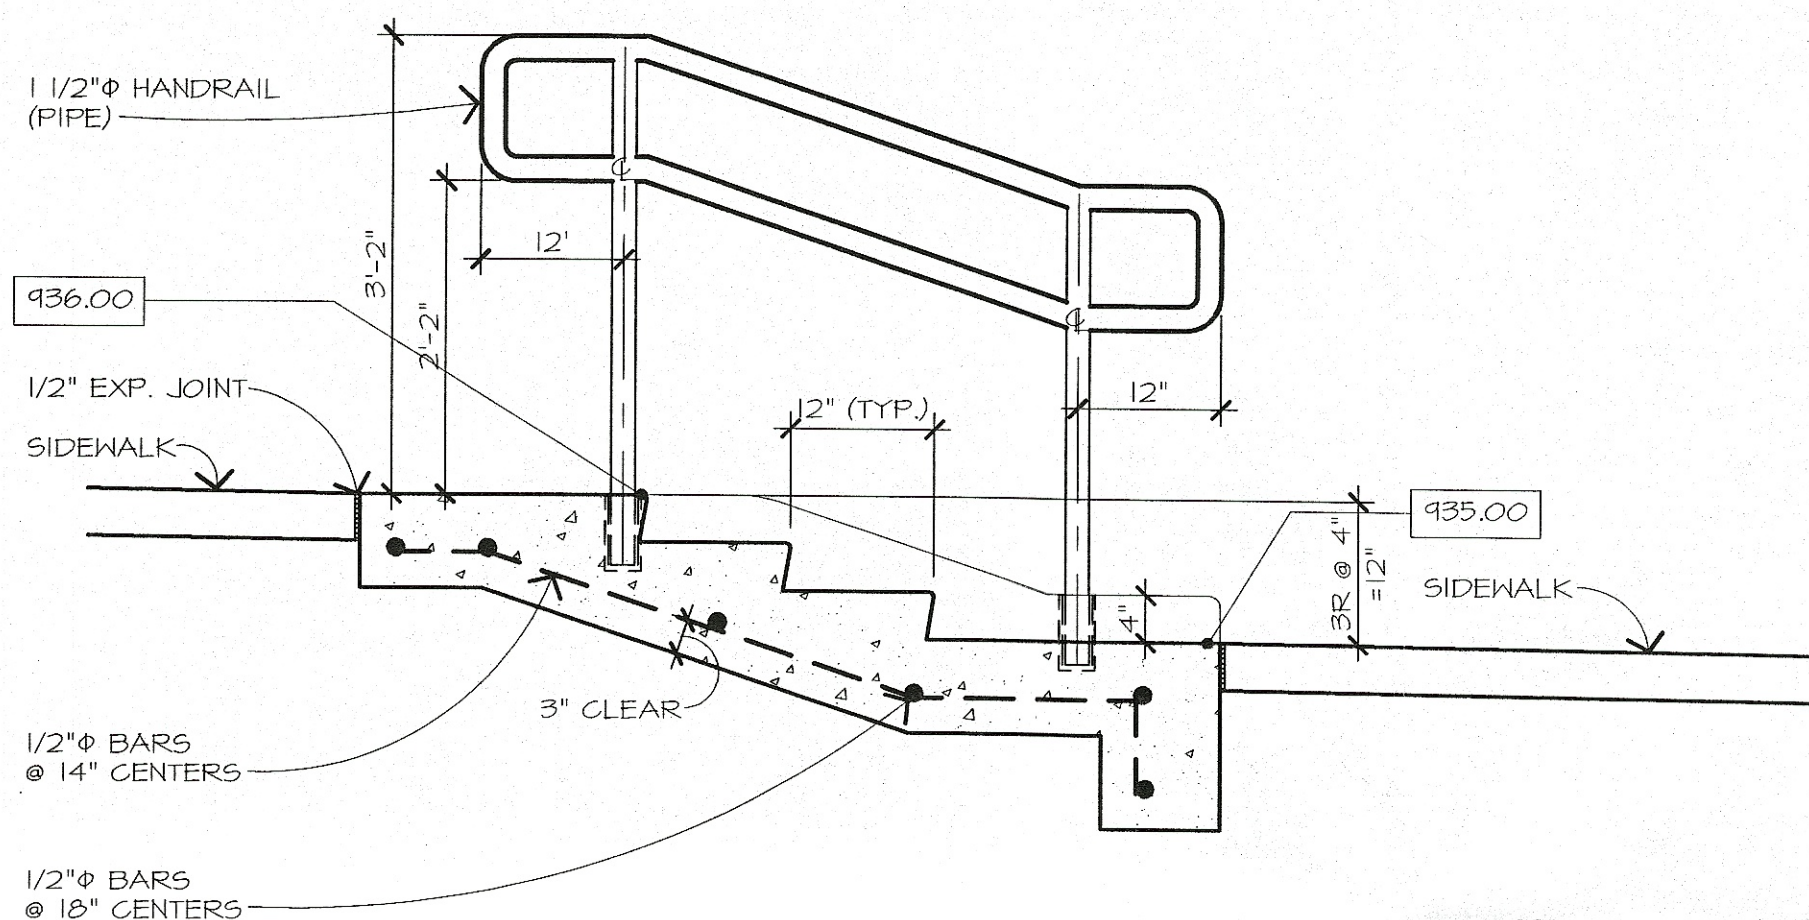


8 Section Thru Stair • 3/4" = 1'-0"

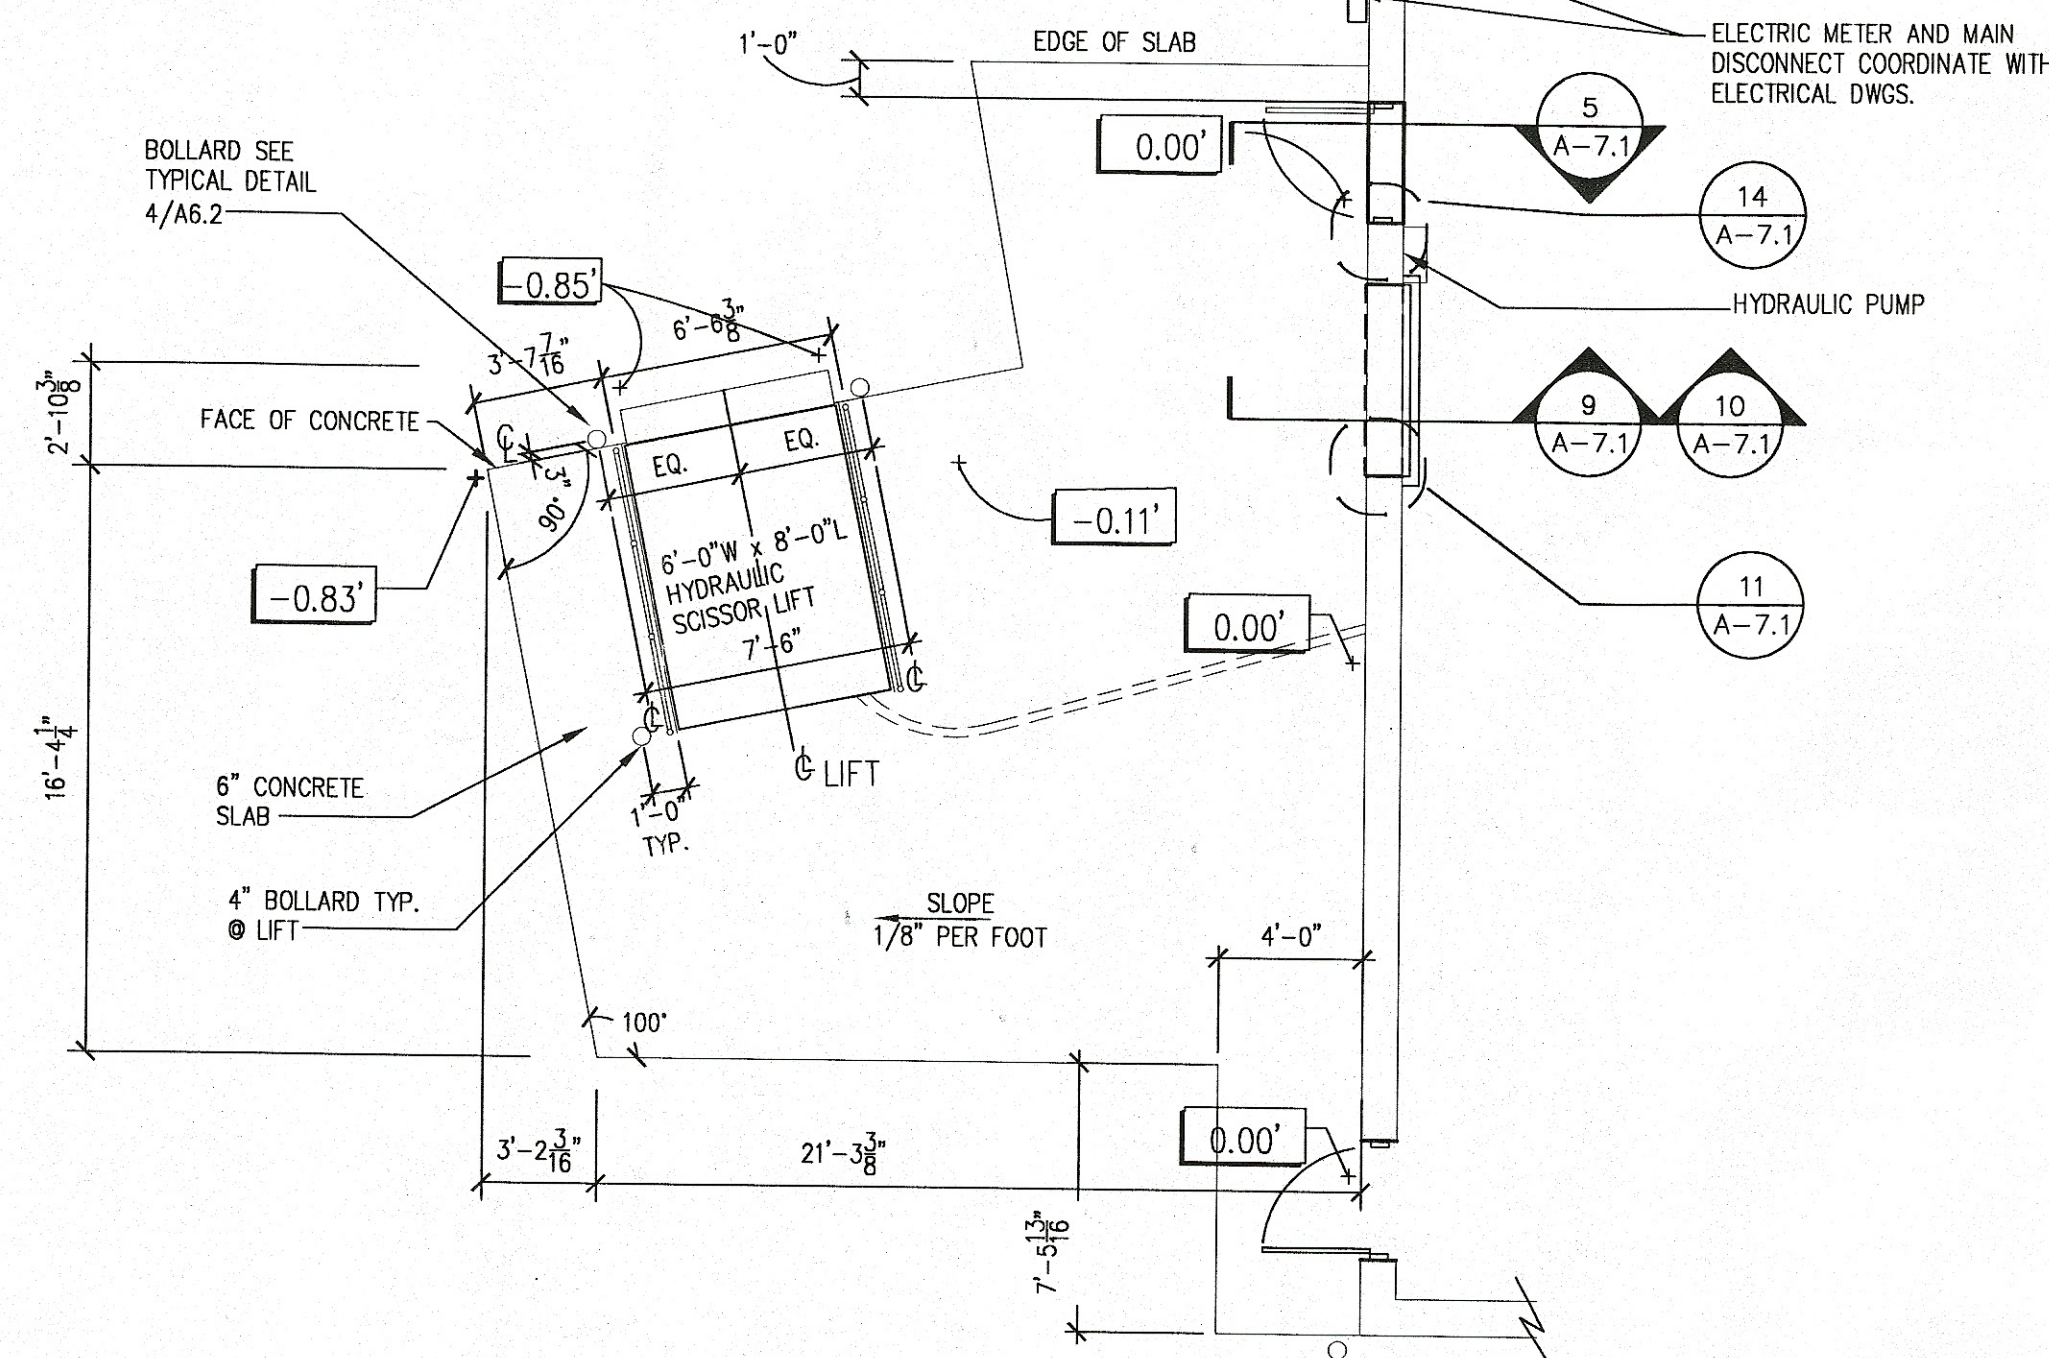

1 PARTIAL FLOOR PLAN - COMPACTOR
A-6.2 SCALE: 3/16" = 1'-0"

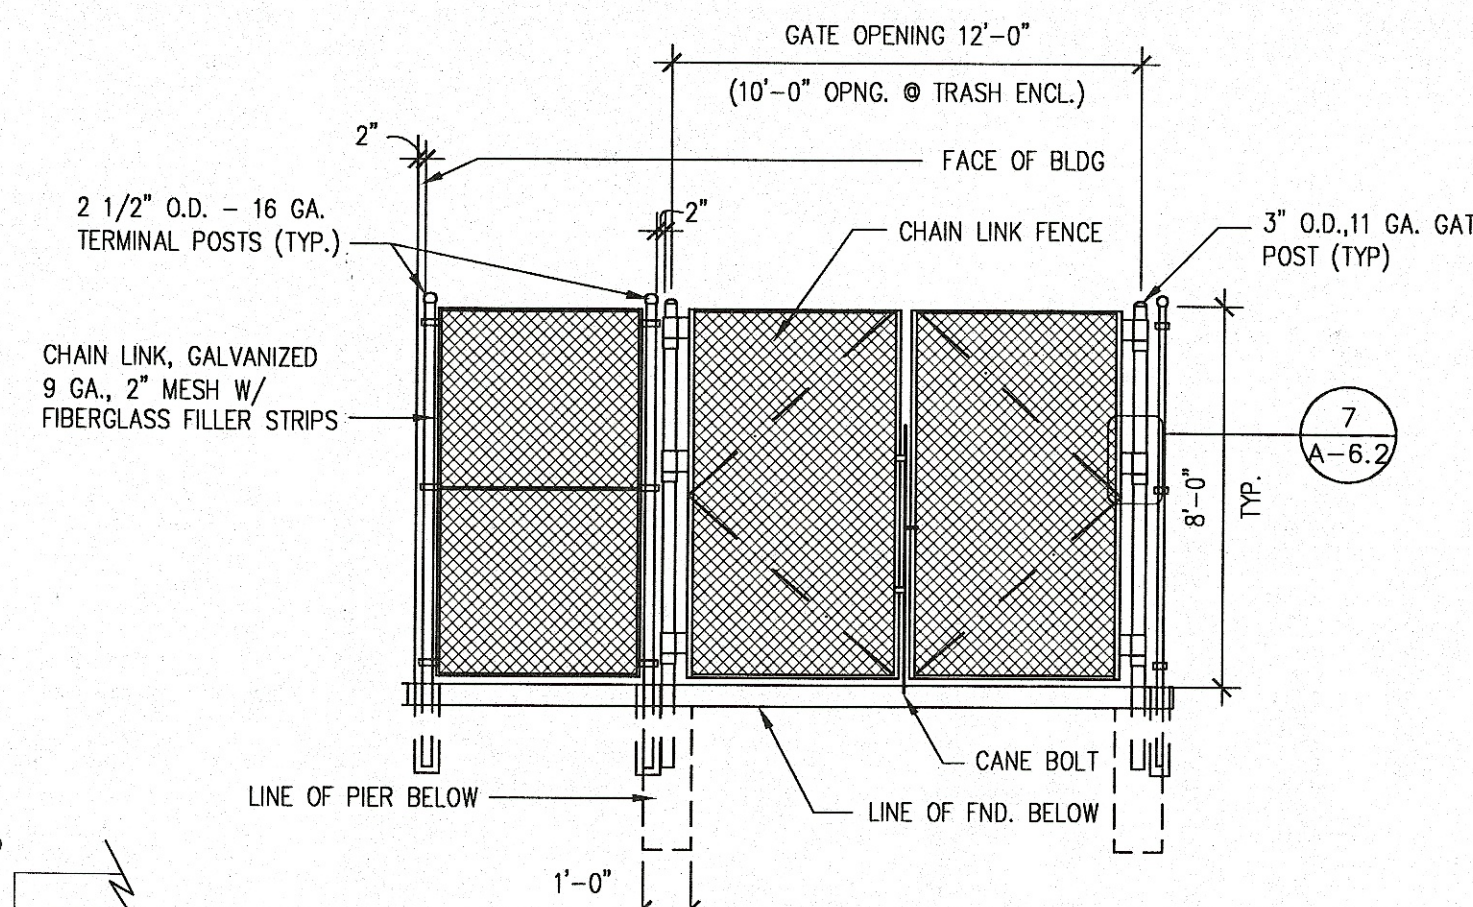


2 GATE ELEVATION
A-6.2 1/4" = 1'-0"

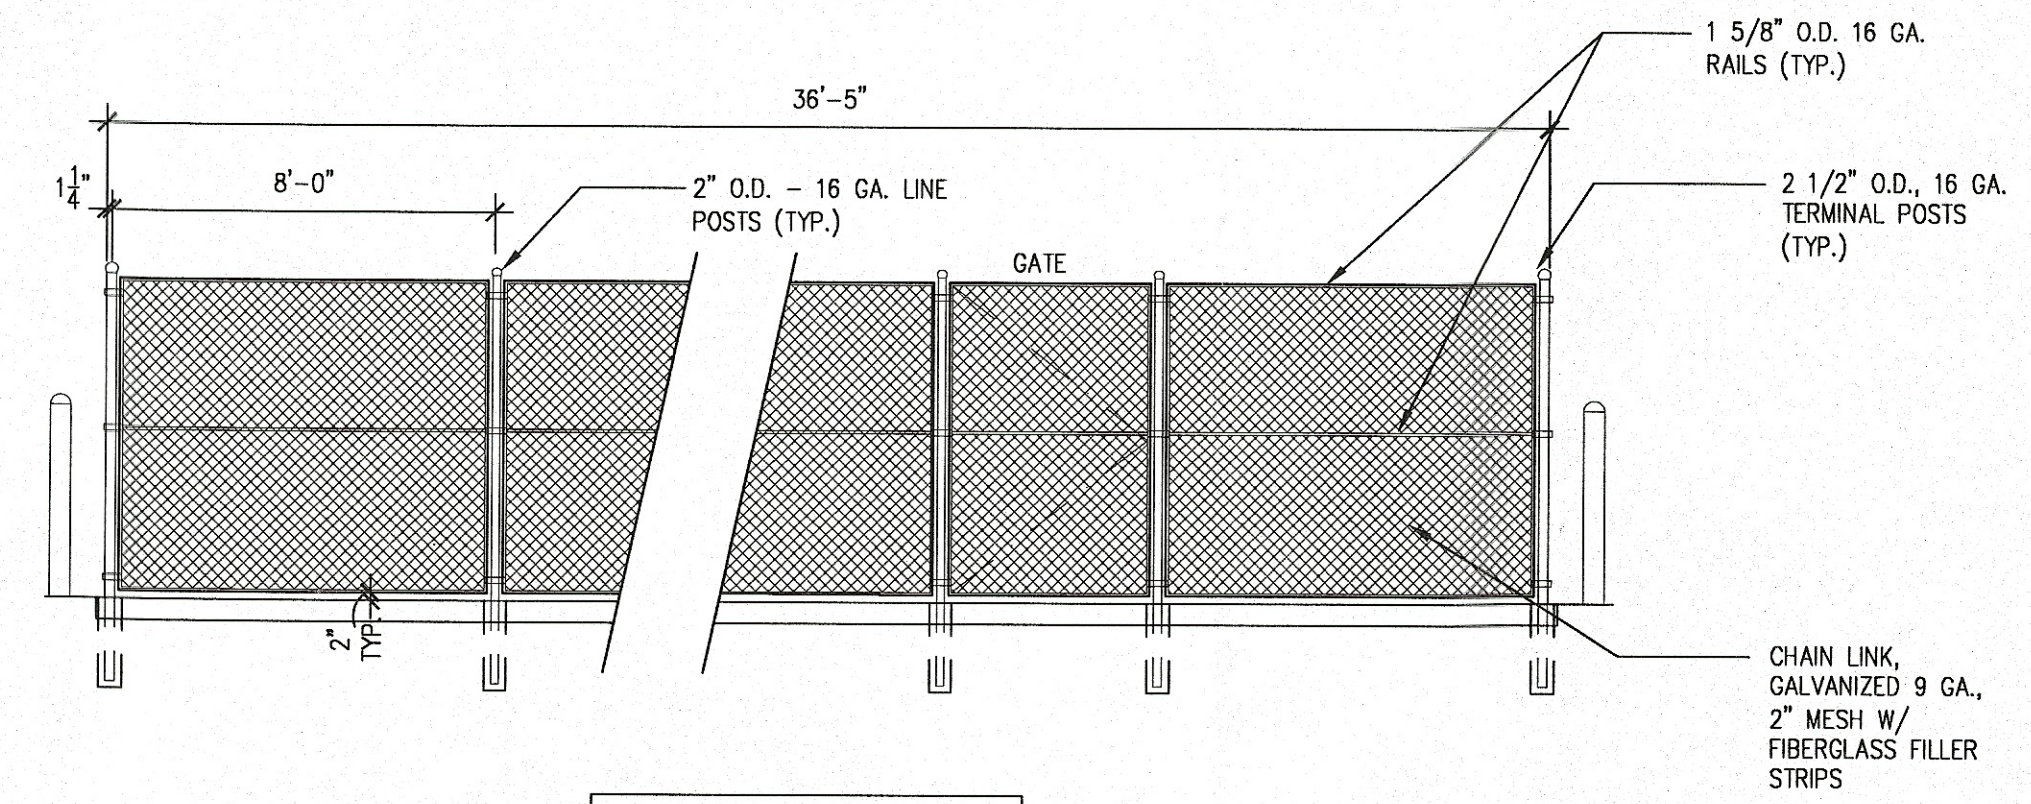


NOTE: SECTIONS & DETAILS ALSO APPLY TO DUMPSTER ENCLOSURE RE: SITE PLAN FOR DUMPSTER LOCATION


3 ELEVATION CHAIN-LINK ENCLOSURE
A-6.2 1/4" = 1'-0"

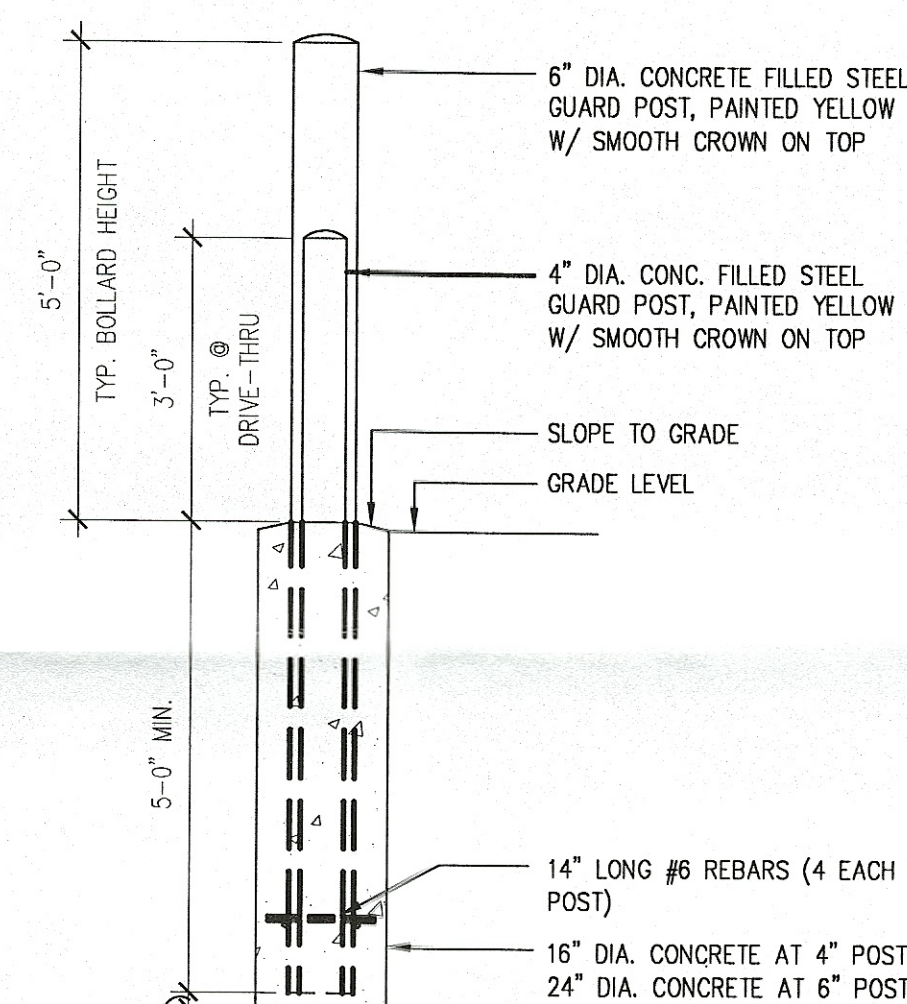

4 BOLLARD DETAIL
A-6.2 1/2" = 1'-0"

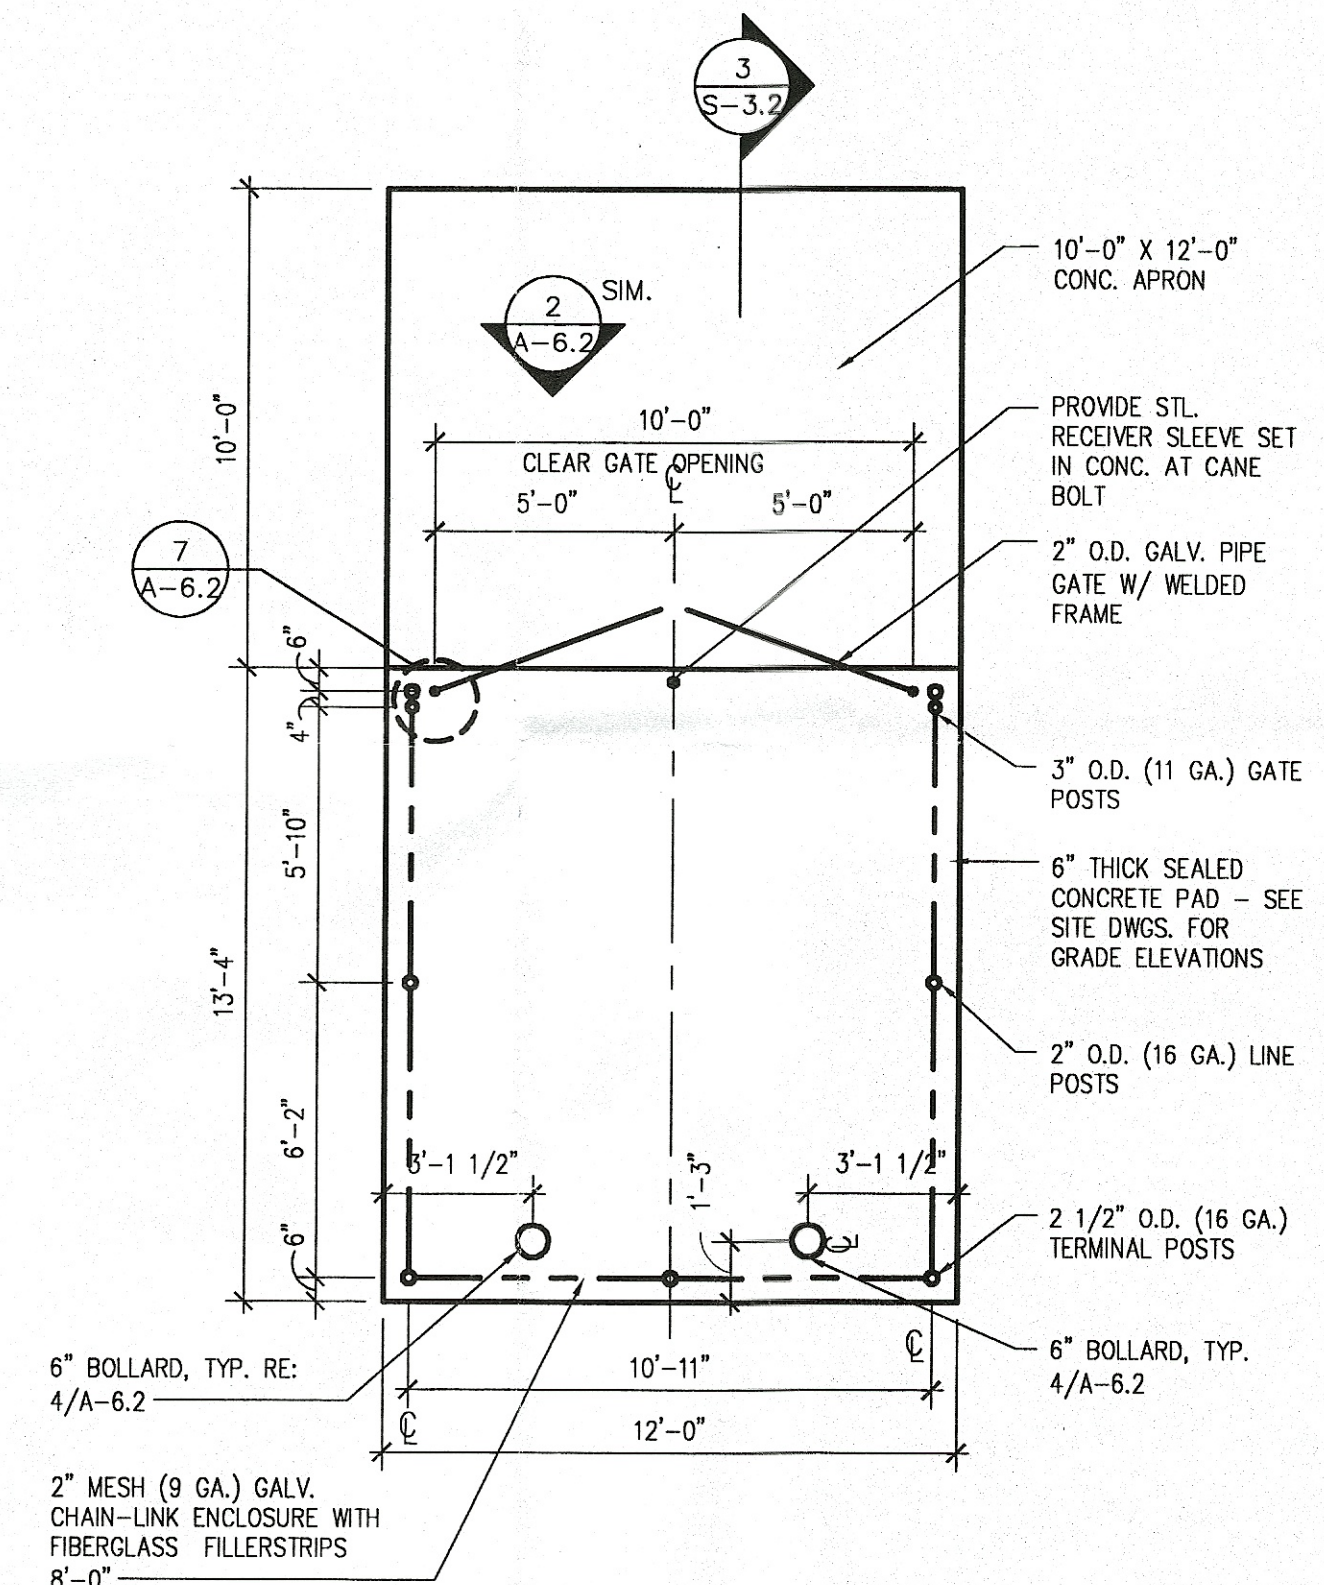


6 TRASH ENCLOSURE PLAN
A-6.2 1/4" = 1'-0"

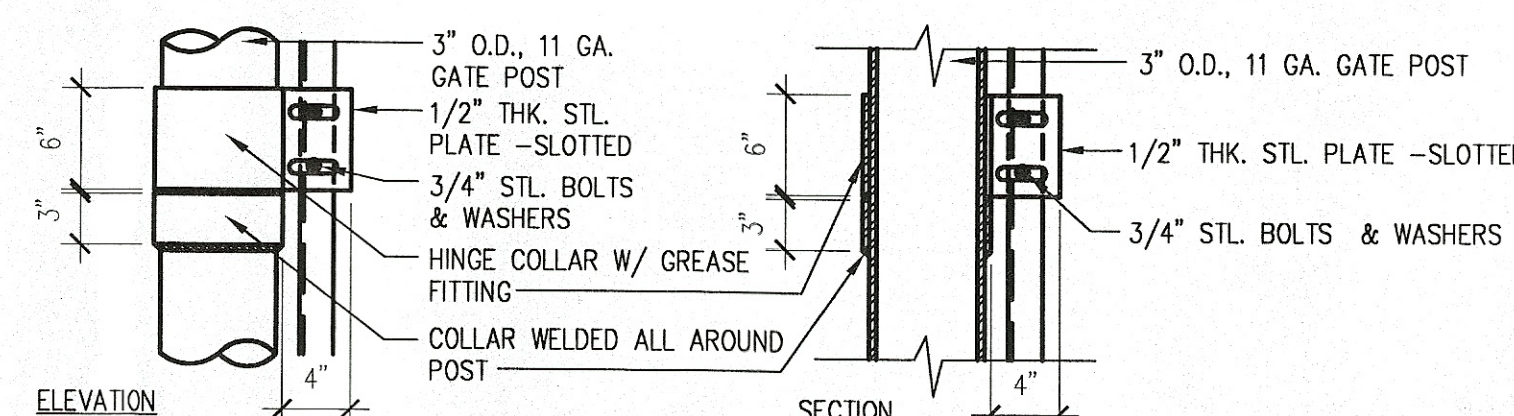


NOTE: SECTIONS & DETAILS ALSO APPLY TO DUMPSTER ENCLOSURE, RE: SITE PLAN FOR DUMPSTER LOCATION

7 TRASH ENCLOSURE
A-6.2 1" = 1'-0"

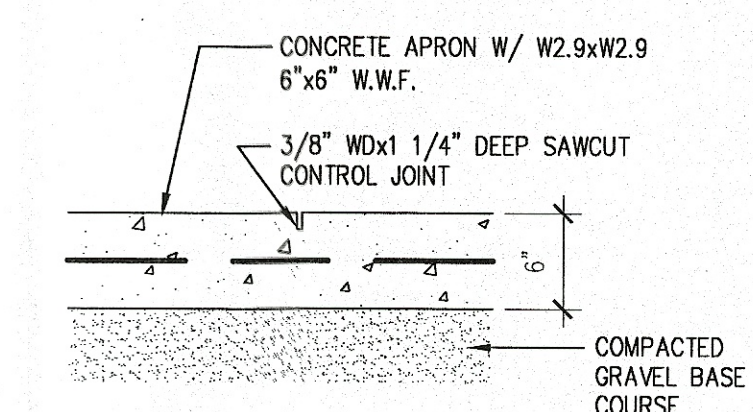

5 CONTROL JOINT DETAIL
A-6.2 1" = 1'-0"

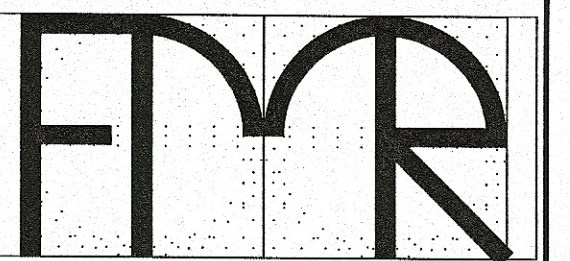

F. Matthew Ray, Architect
3384 West Twelve Mile Road
Berkley, Michigan 48072

T. (248) 744-3384
F. (248) 744-3388
E. FMRayArch@AOL.COM



CONSULTANT:

DRAWING ALTERATION
IT IS A VIOLATION OF LAW FOR ANY PERSON, UNLESS ACTING UNDER THE DIRECTION OF A LICENSED ARCHITECT, PROFESSIONAL ENGINEER, LANDSCAPE ARCHITECT, OR LAND SURVEYOR TO ALTER ANY ITEM ON THIS DOCUMENT.

ANY LICENSEE WHO ALTERS THIS DOCUMENT IS REQUIRED BY LAW TO AFFIX HIS OR HER SEAL AND THE NOTATION "ALTERED BY FOLLOWED BY HIS OR HER SIGNATURE AND SPECIFIC DESCRIPTION OF THE ALTERATIONS."

SEAL:

CVS/
pharmacy

STORE NUMBER: #4420
242 LINCOLN WAY WEST
MASSILLON, OH 44646

DEVELOPER:

ZAREMBA GROUP
14600 Detroit Ave., Suite 1500
Lakewood, Ohio 44107
TEL (216) 221-6600
FAX (216) 221-1031
CONTACT: Bruce Noggle

REVISIONS:

LAYOUT COORD: 0000
PLANNING MGR. MEH
DRAWING BY:
DATE: March 15, 2001
JOB NUMBER: 01007
TITLE:

ENLARGED PLANS & DETAILS

SHEET NUMBER:

A-6.2

COMMENTS:

BIDS & PERMITS

DO NOT SCALE DRAWINGS