

3


4

2

1

6 7 5

1	2	3	4	5	6	7	8	9	10	11	
										FLOORING L	EGEND ALT 1
										RUB-1 F	RUBBER TILE
										RUB-2	RUBBER TILE
										RUB-3	RUBBER TILE
										RUB-4	RUBBER TILE
										RUB-5	RUBBER TILE
										RUB-6	RUBBER TILE
				LM <u>S ROOM</u>	1.1E <u>CH.ROO</u> N - AZ7985		_			RUB-7 F	RUBBER TILE
					-	A-101-A A-TOT-C				RUB-8	RUBBER TILE
										RUB-9	RUBBER TILE
-	A-101-A A-101-C			2ND GRAD						RUB-10	RUBBER TILE

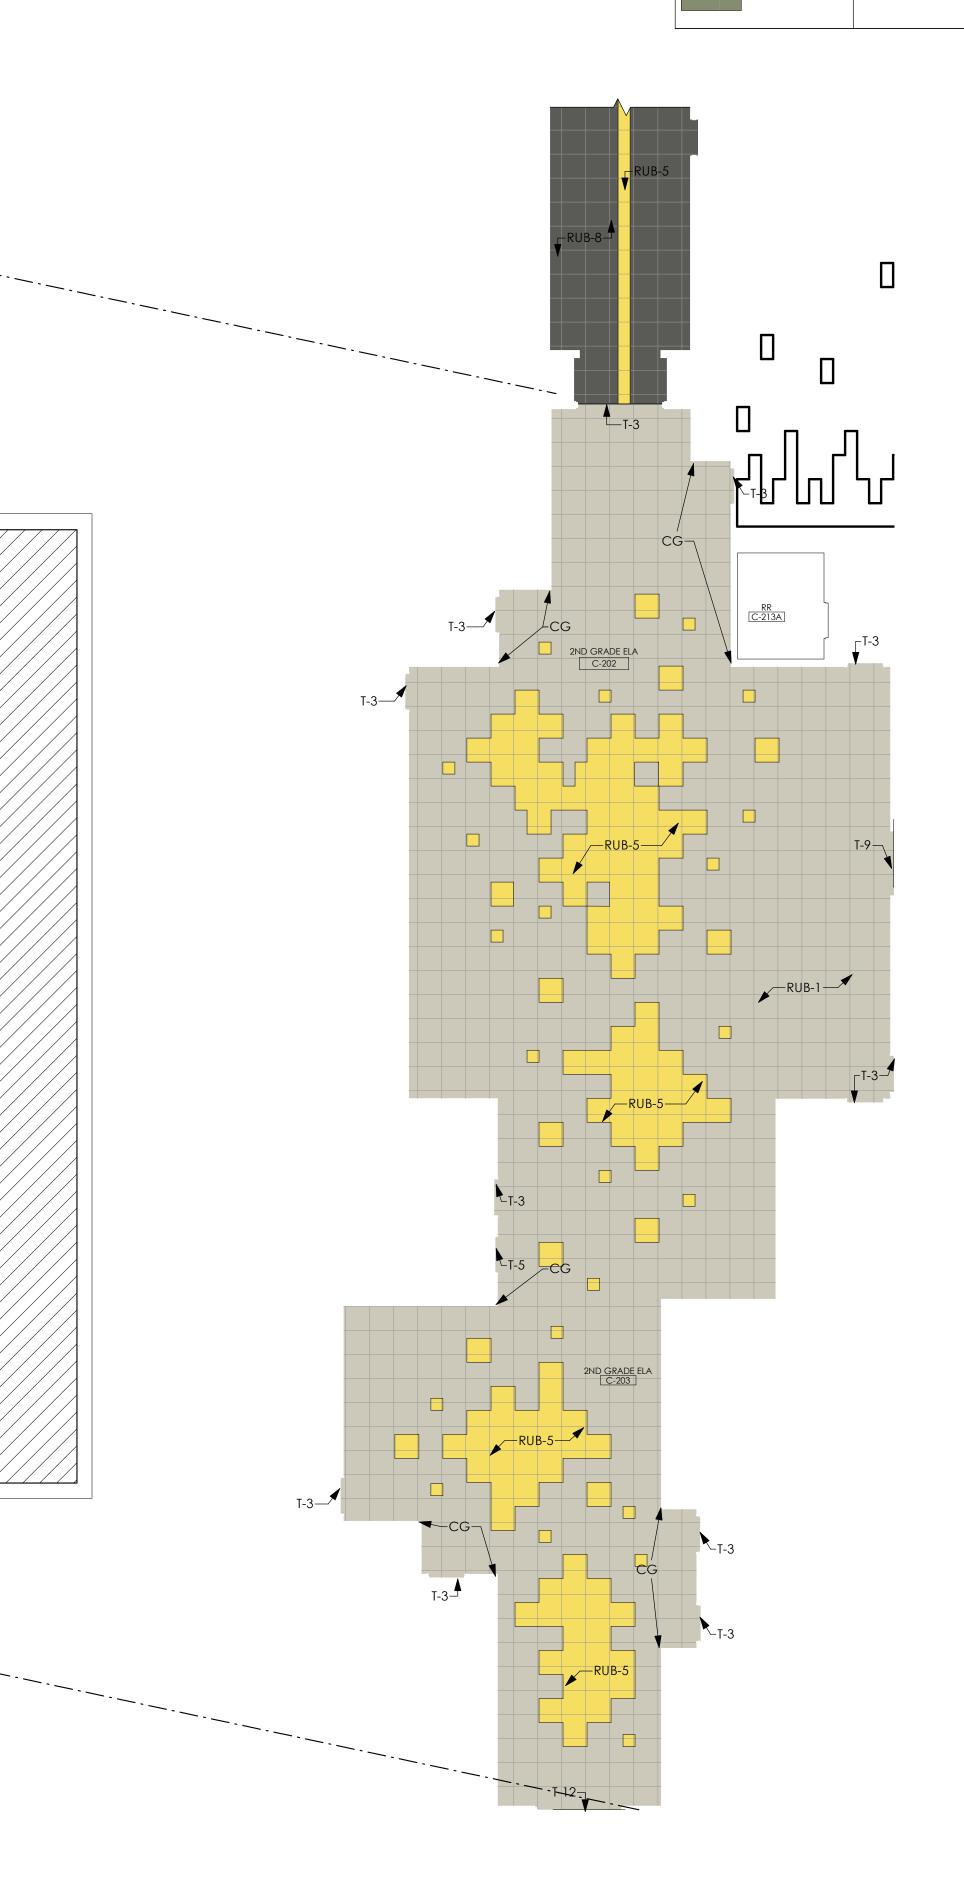

12


9

10

11

8

LVT-1		- 1	1		
	LUXURY VINYL TILE	L	DT.		Ŋ
LVT-2	LUXURY VINYL TILE				0HI0 44145
LVT-3	LUXURY VINYL TILE		0 U F	S	OIH(
LVT-4	LUXURY VINYL TILE		G R	PLANNERS	
LVT-5	LUXURY VINYL TILE	к	Z O	PLA	EVELAND,
LVT-6	LUXURY VINYL TILE		VISI	0	CLE
LVT-7	LUXURY VINYL TILE			TS	DRIVE
LVT-8	LUXURY VINYL TILE	J	URAL	ARC HITECTS	
LVT-9	LUXURY VINYL TILE		ECT	ARC	SPERRY
LVT-10	LUXURY VINYL TILE		Ш Н Н Н		3850 9
CPT-1	CARPET TILE		ARC		238
CPT-2	CARPET TILE	н	4		
CPT-3	CARPET TILE				
CPT-4	CARPET TILE				
CPT-5	CARPET TILE	G		11111111111111111111111111111111111111	
CPT-6	CARPET TILE			SYED S. ∴ ABBAS … 10376 …☆	d Archite
LIN-1	LINOLEUM		PROFESSIONAL SEAL:	₹ 	Ren Print
LIN-2	LINOLEUM		PA		
LIN-3	LINOLEUM	F			
LIN-4	LINOLEUM		CONSULTANT:		
LIN-5	LINOLEUM		-	K-X	9
LIN-6	LINOLEUM	E		EMENTARY PK-3	0 4462
LIN-7	LINOLEUM		LS	NTA	N, OHI
LIN-8	LINOLEUM		MASSILLON CITY SCHOOLS	EME	VSILLC
PFT-1	PORCELAIN FLOOR TILE		N CITY	Ш	OWN DRIVE SE, MASSILLON, OHIO 44646
CG	STAINLESS STEEL CORNER GUARD	D	SSILLOI	EAST	DRIVE
 ALL LINOLEUM MUST SEE INTERIOR ELEVATI SEE RESTROOM PLAN SEE FINISH PLAN FOR ALL EXPOSED SIDES C ALL PRODUCTS SHOW MANUFACTURERS TH APPROVAL SEE FINISH PLANS FOR SEE FINISH PLANS FOR LINOLEUM SEAMS SH SHOWER CLEARANCH PLUMBING FIXTURES A FROM FINISH DIMENS CONTRACTOR TO PR TECHNOLOGY, RESTR WOOD DOOR COLO DURING SHOP DRAW HOLLOW METAL DOOR ELEVATIONS CORNER GUARDS INI ALL FLOOR CONTROL JOINT IS GREATER TH JOINTS WITH 100% SC CONTRACTOR TO PR SEE A-651 FOR FINISH SEE INTERIOR ELEATION 	OVIDE BLOCKING BEHIND STUD WALLS WHERE CASEWORK, SHELVING, OOM ACCESSORIES, ETC. IS MOUNTED R TO BE SELECTED BY ARCHITECT FROM MANUFACTURER'S FULL RANGE OF COLORS ING PHASE DR AND FRAME COLOR TO BE PT-1 UNLESS NOTED OTHERWISE ON INTERIOR DICATED ON FINISH PLAN AS 'CG' JOINTS AS INDICATED ON FINISH PLAN ARE TO BE 1/4 DEPTH OF SLAB THICKNESS. IF AN 1/2" DEEP, FILL WITH FOAM BACKER ROD 1/8" WIDER THAN JOINT. FILL ALL DUIDS EPOXY FILLER COLOR MATCHED TO CONCRETE. OVIDE WALK OFF MATS AT ALL BUILDING ENTRANCES SCHEDULE DNS FOR GYPSUM CONTROL JOINT LOCATIONS. SEE A-652 FOR DETAIL.	C	W	MASSILLON	DESIGN DEVELOPMENT 1 PAUL E BR
20. CONTINUE FINISH FLC	KEY PLAN	В	PROJECT NO DRAWN BY CHECKED BY DATE	Author	5 03.17.23

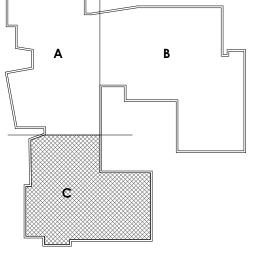

13 14

SHEET NO A-941-C

SCALE: As indicated