


MUSIC ROOM, INSTRUMENTAL ROOM, AND VOCAL ROOMS AUDIO SYSTEM RISER DIAGRAM

AUDIO RISER NOTES:


- 1. RISER IS TYPICAL OF (3) COMPLETE SYSTEMS.
- 2. DIAGRAM IS REPRESENTATIONAL ONLY. CONTRACTOR SHALL VERIFY EXACT CABLING REQUIREMENTS, ESTABLISH A PROJECT SPECIFIC RISER DIAGRAM AND SUBMIT SAME FOR APPROVAL BY THE ENGINEER. CONTRACTOR SHALL INSTALL PER THE APPROVED DIAGRAM AND THE MANUFACTURERS RECOMMENDATIONS AND INSTRUCTIONS.
- 3. ALL INSTALLATION, MATERIALS AND WORKMANSHIP SHALL BE PER LOCAL, STATE AND FEDERAL CODES AND REGULATIONS, INCLUDING, BUT NOT LIMITED TO NFPA 70 (NEC), AND NFPA 101, AS WELL AS INDUSTRY STANDARDS.
- 4. AUDIO VISUAL SYSTEM CONTRACTOR SHALL COORDINATE EXACT POWER REQUIREMENTS AND CONNECTIONS WITH THE ELECTRICAL CONTRACTOR.
- 5. AUDIO VISUAL SYSTEM CONTRACTOR SHALL PROVIDE ALL JUMPERS AND CABLING REQUIRED TO COMPLETE ALL INTERCONNECTIONS OF THE SYSTEM. ALL ETHERNET NETWORK CABLING BOTH COPPER AND FIBER SHALL BE COMPLIANT WITH THE STRUCTURED CABLING SPECIFICATION SECTION 27 10 00, AND SHALL MATCH THE MANUFACTURER AND PERFORMANCE RATING OF THE STRUCTURED CABLING REQUIREMENTS. VERIFY THESE REQUIREMENTS
- 6. CONDUITS THROUGH WHICH CABLING SHALL BE ROUTED ARE PURPOSELY NOT SHOWN ON THIS RISER TO IMPROVE DIAGRAM CLARITY. FOR CABLING ENTERING AND/OR EXITING AUDIO SYSTEM CABINET, CONTRACTOR SHALL UTILIZE CONDUITS AS INDICATED ON THE AV CABINET ROUGH-IN DETAIL ON DRAWING T-502.



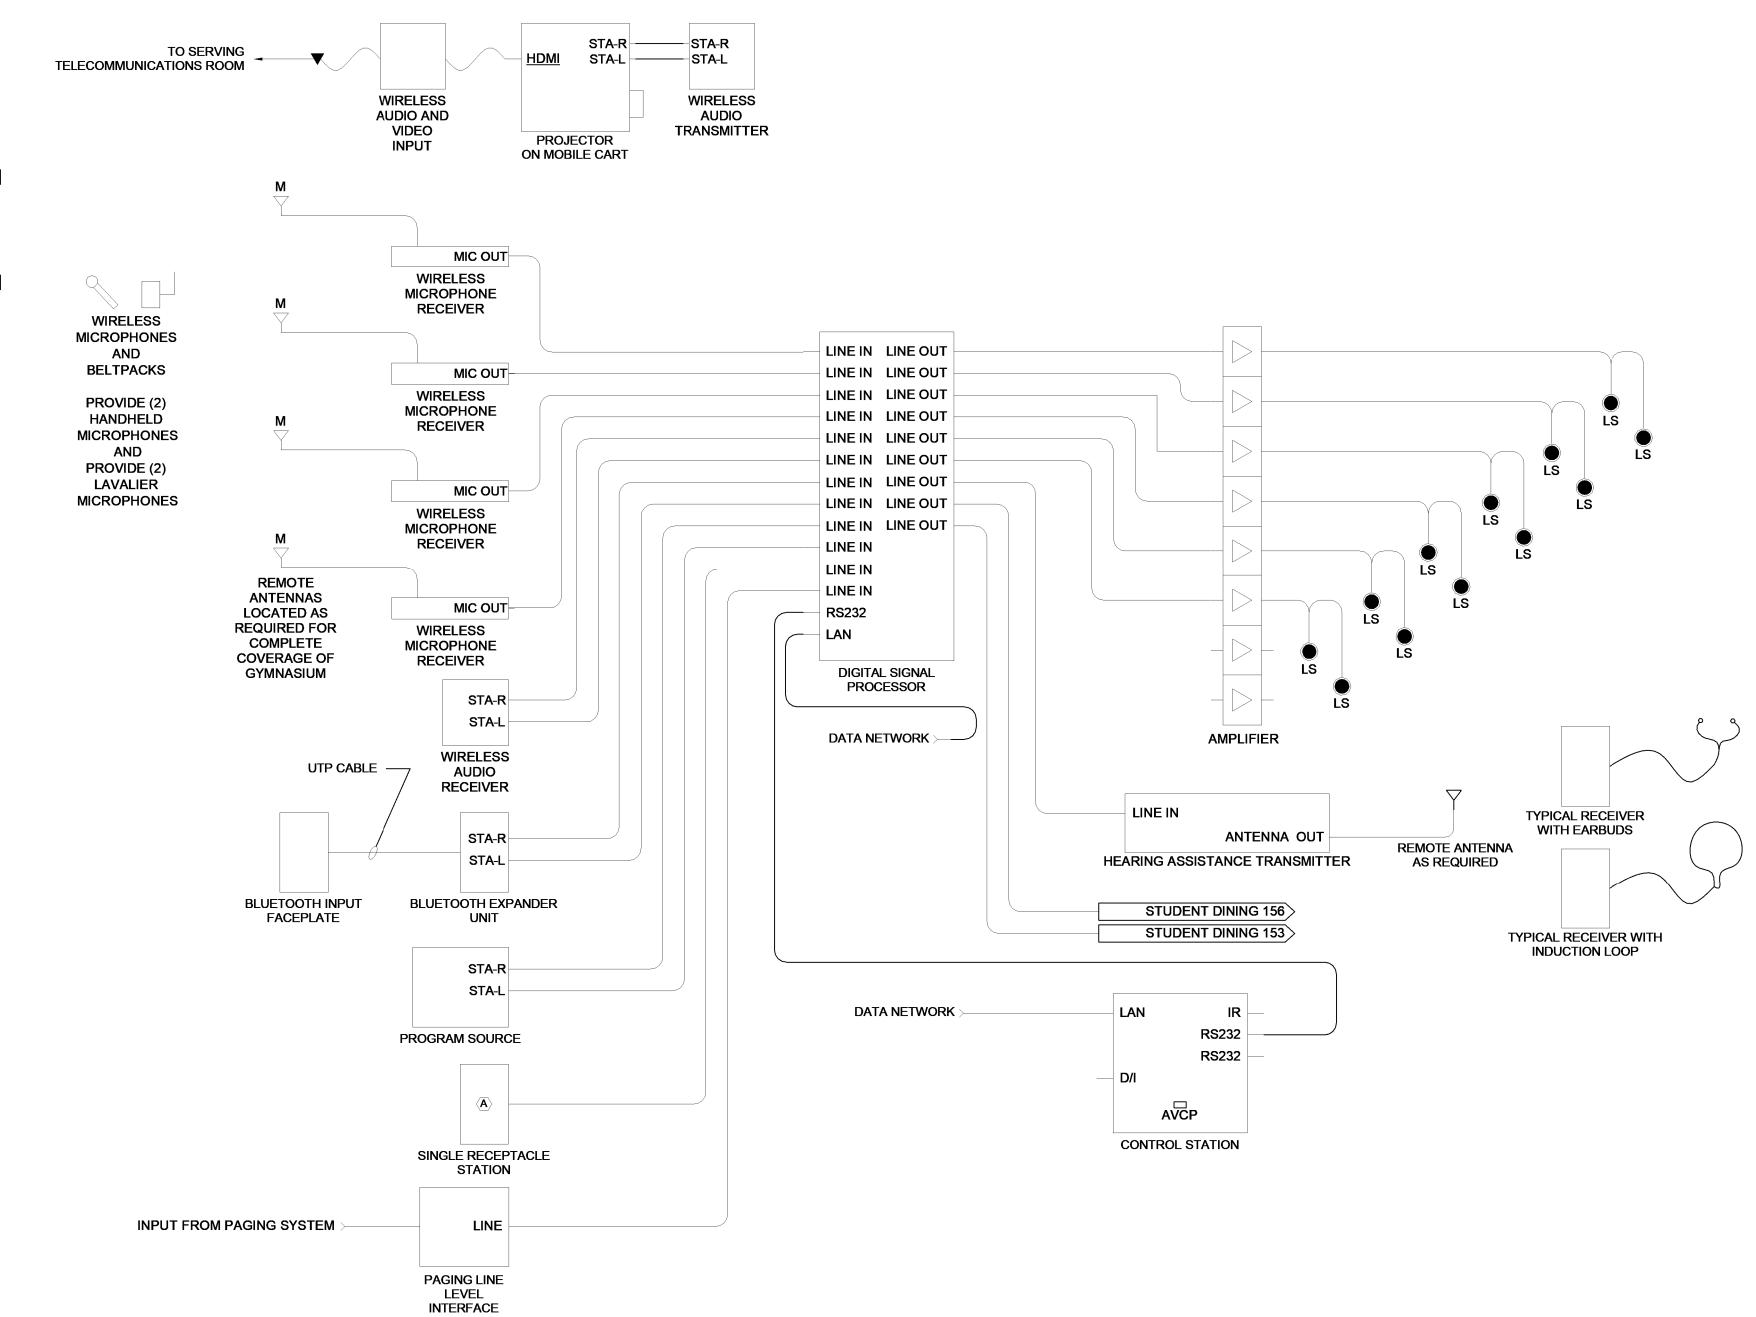


RISER DIAGRAM NOTES:

- 1. DIAGRAM IS REPRESENTATIONAL ONLY. CONTRACTOR SHALL VERIFY EXACT CABLING REQUIREMENTS, ESTABLISH A PROJECT SPECIFIC RISER DIAGRAM AND SUBMIT SAME FOR APPROVAL BY THE ENGINEER. CONTRACTOR SHALL INSTALL PER THE APPROVED DIAGRAM AND THE MANUFACTURERS RECOMMENDATIONS AND INSTRUCTIONS.
- 2. DIAGRAM IS REPRESENTATIONAL OF (2) SYSTEMS.
- 3. ALL INSTALLATION, MATERIALS AND WORKMANSHIP SHALL BE PER LOCAL, STATE AND FEDERAL CODES AND REGULATIONS, INCLUDING, BUT NOT LIMITED TO NFPA 70 (NEC), AND NFPA 101, AS WELL AS INDUSTRY STANDARDS.
- 4. AUDIO VISUAL SYSTEM CONTRACTOR SHALL COORDINATE EXACT POWER REQUIREMENTS AND CONNECTIONS WITH THE ELECTRICAL CONTRACTOR.
- 5. AUDIO VISUAL SYSTEM CONTRACTOR SHALL PROVIDE ALL JUMPERS AND CABLING REQUIRED TO COMPLETE ALL INTERCONNECTIONS OF THE SYSTEM. ALL ETHERNET NETWORK CABLING BOTH COPPER AND FIBER SHALL BE COMPLIANT WITH THE STRUCTURED CABLING SPECIFICATION SECTION, AND SHALL MATCH THE MANUFACTURER AND PERFORMANCE RATING OF THE STRUCTURED CABLING REQUIREMENTS. VERIFY THESE REQUIREMENTS WITH THE STRUCTURED CABLING CONTRACTOR.

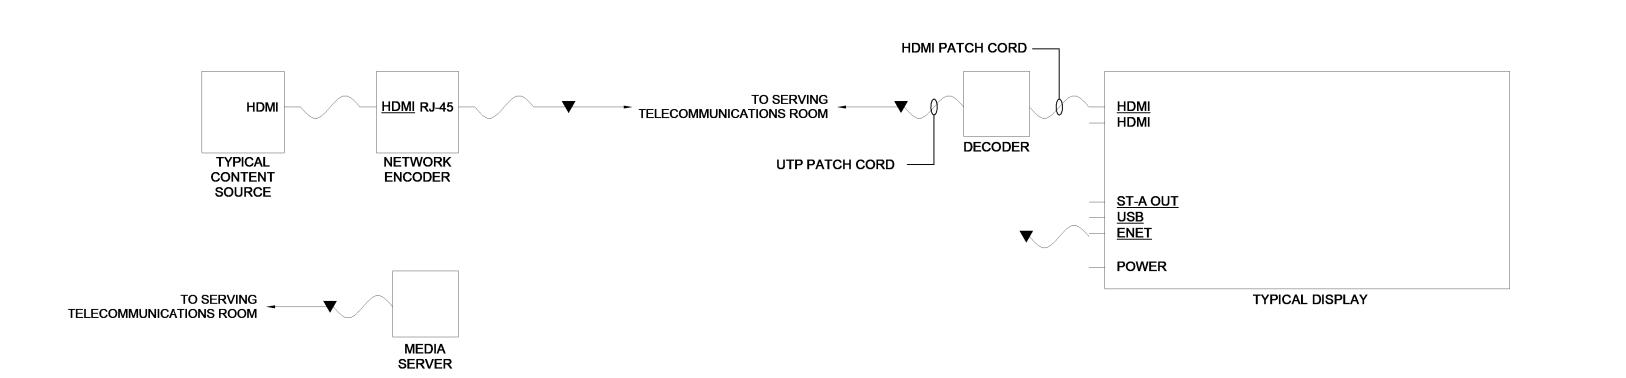



2203-2

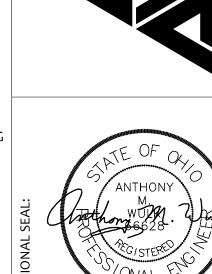





BICSI ID # 181837R

PROJECT NO 2203-2 DRAWN BY DRK

CHECKED BY AMW 07/12/23

TECHNOLOGY RISER DIAGRAMS

SCALE: 1/8" = 1'-0" SHEET NO