

10 CORNER CASEKWORK SECTION
1" = 1'-0"

ELEVATION 3/8" = 1'-0"

7 ELEVATION 3/8" = 1'-0"


8 ELEVATION 3/8" = 1'-0"

SINK SCHEDULE SINK TYPE | BOWL SIZE MATERIAL SINGLE (ADA) 20"L X 19 1/2"WX 6"D 3 HOLES FAUCET SEE PLUMBING DRAWINGS FOR FULL SINK TYPE SPECIFICATIONS AS WELL AS OTHER PLUMBING FIXTURES APPLIANCE SCHEDULE TOP FREEZER REFRIGERATOR (18.2 CU. FT.) 28"W X 32 3/8"D X 67 3/8"H LOCKABLE DOOR COUNTERTOP MICROWAVE OVEN (1.6CU. FT.) 29 7/8"W X 15 5/32"D X 16 3/16"H RANGE | ELECTRIC SMOOTH TOP RANGE WITH OVEN (5.3 CU. FT.) 29 7/8" X 27 3/4"D X 46 7/8"H BUILT IN DISHWASHER 24"W X 25 3/4"D X 34"H FIXED EQUIPMENT SCHEDULE E1 PENCIL SHARPENER AND SUPPORT TD PAPER TOWEL DISPENSER MARKER BOARD (WHITE BOARD) SPECIAL FOR PROJECTING TB TACK BOARD MRR MIRROR TECHNOLOGY EQUIPMENT CP BRIGHT LINK CEILING PROJECTOR


TYPICAL CASEWORK NOTES

PRINTER OR FAX

- VERIFICATION OF BUILDING DIMENSIONS TO BE CONFIRMED BY GENERAL CONTRACTOR PRIOR TO CONSTRUCTION. WALL/FLOOR AREA SPECIFIED FOR PRODUCT INSTALLATION MUST BE FREE
- OF OBSTRUCTIONS SUCH AS LIGHT SWITCHES, OUTLETS, HVAC, CLOCK, SEE TECHNOLOGY DWGS.S, SIGNS, ETC. CASEWORK SUPPLIER TO PROVIDE FILLER PIECES AFTER REVIEWING DRAWINGS AND GENERAL CONTRACTOR PERFORMS VERIFICATION OF
- **BUILDING DIMENSIONS.** END COVER PANELS AND FILLER PIECES ARE TO BE INCLUDED IN BID PRICE AND SHOWN AS PER DRAWING AND AS DETERMINED IN FIELD FROM
- **BUILDING DIMENSION VERIFICATION.** CORNER CABINET PLACEMENTS TO BE VERIFIED BY CABINET INSTALLER.
- 6. CASEWORK SUPPLIER TO PROVIDE FINISHED END PANELS WHERE **CASEWORK IS EXPOSED / VISIBLE.** 7. IF ELECTRICAL OUTLETS OR RACEWAYS ARE LOCATED INSIDE OR BEHIND OR ARE PART OF THE CABINET, CASEWORK MANUFACTURER SHALL PROVIDE
- CUTOUTS AND COORDINATE CUTOUT SIZE AND LOCATION IN FIELD WITH **ELECTRICAL CONTRACTOR.** 8. IF CASEWORK IS LOCATED IN FRONT OF WINDOWS AND HIGHER THAN THE WINDOW SILL, THAT CABINET SHOULD HAVE FINISHED BACK. VERIFY IN
- 9. PROVIDE FIRE RETARDANT TREATED BLOCKING AS REQUIRED FOR CABINET AND METAL SHELF ATTACHMENT IN M ETAL FRAMED STUD WALLS. 10. ROUGH OPENING OF 7'-6" IS REQUIRED FOR TALL CABINET INSTALLATION.
- 11. SEE AF-501 FOR TYPICAL CASEWORK MOUNTING HEIGHTS 12. CONTRACTOR TO INCLUDE PRICE FOR LABOR AND MATERIAL FOR GROMMETS AS NEEDED. GROMMETS SHALL BE 3" ROUND, COLOR SELECTED BY INTERIOR DESIGNER. HOLES ARE TO BE CUT IN CASEWORK IN FIELD. LOCATIONS TO BE DETERMINED BY ARCHITECT.
- 13. SEE ELEVATIONS FOR DOOR SWING. 14. LAMINATE COLOR TO BE CHOSEN BY ARCHITECT FROM MANUFACTURER'S **FULL RANGE OF COLORS.**

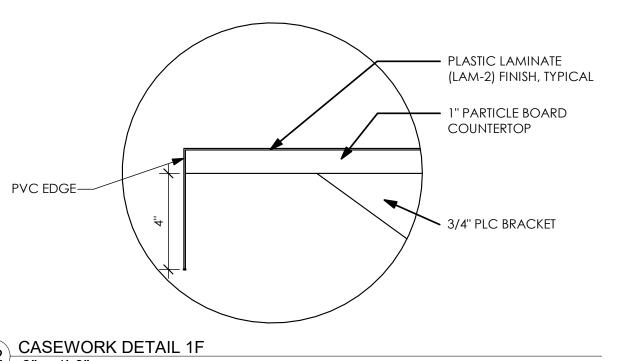

12 CASEWORK DETAIL 1F 3" = 1'-0"

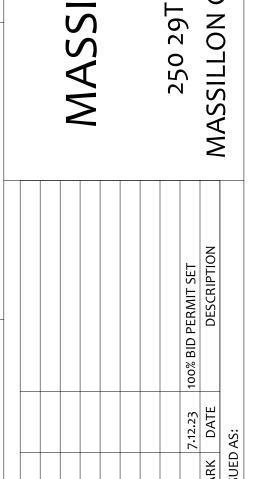

SCHO(ELE

AASSI ON

PROJECT NO

2203-1

PROJECT NO 2203-1 DRAWN BY Author CHECKED BY Checker

CASEWORK DETAILS AND SCHEDULE

SCALE: As indicated SHEET NO

AF-502