


DO NOT REMOVE
FROM FILE ROOM

ADDITION TO LAUNDRY MASSILLON STATE HOSPITAL MASSILLON, OHIO.




STATE OF OHIO
DEPARTMENT OF MENTAL HYGIENE
AND CORRECTION

PREPARED FOR
DEPARTMENT OF PUBLIC WORKS
ALFRED C. GIENOW - DIRECTOR
CARL E. BENTZ - CONSULTING ARCHITECT

PREPARED BY
DEPARTMENT OF MENTAL HYGIENE AND CORRECTION
ENGINEERING SECTION

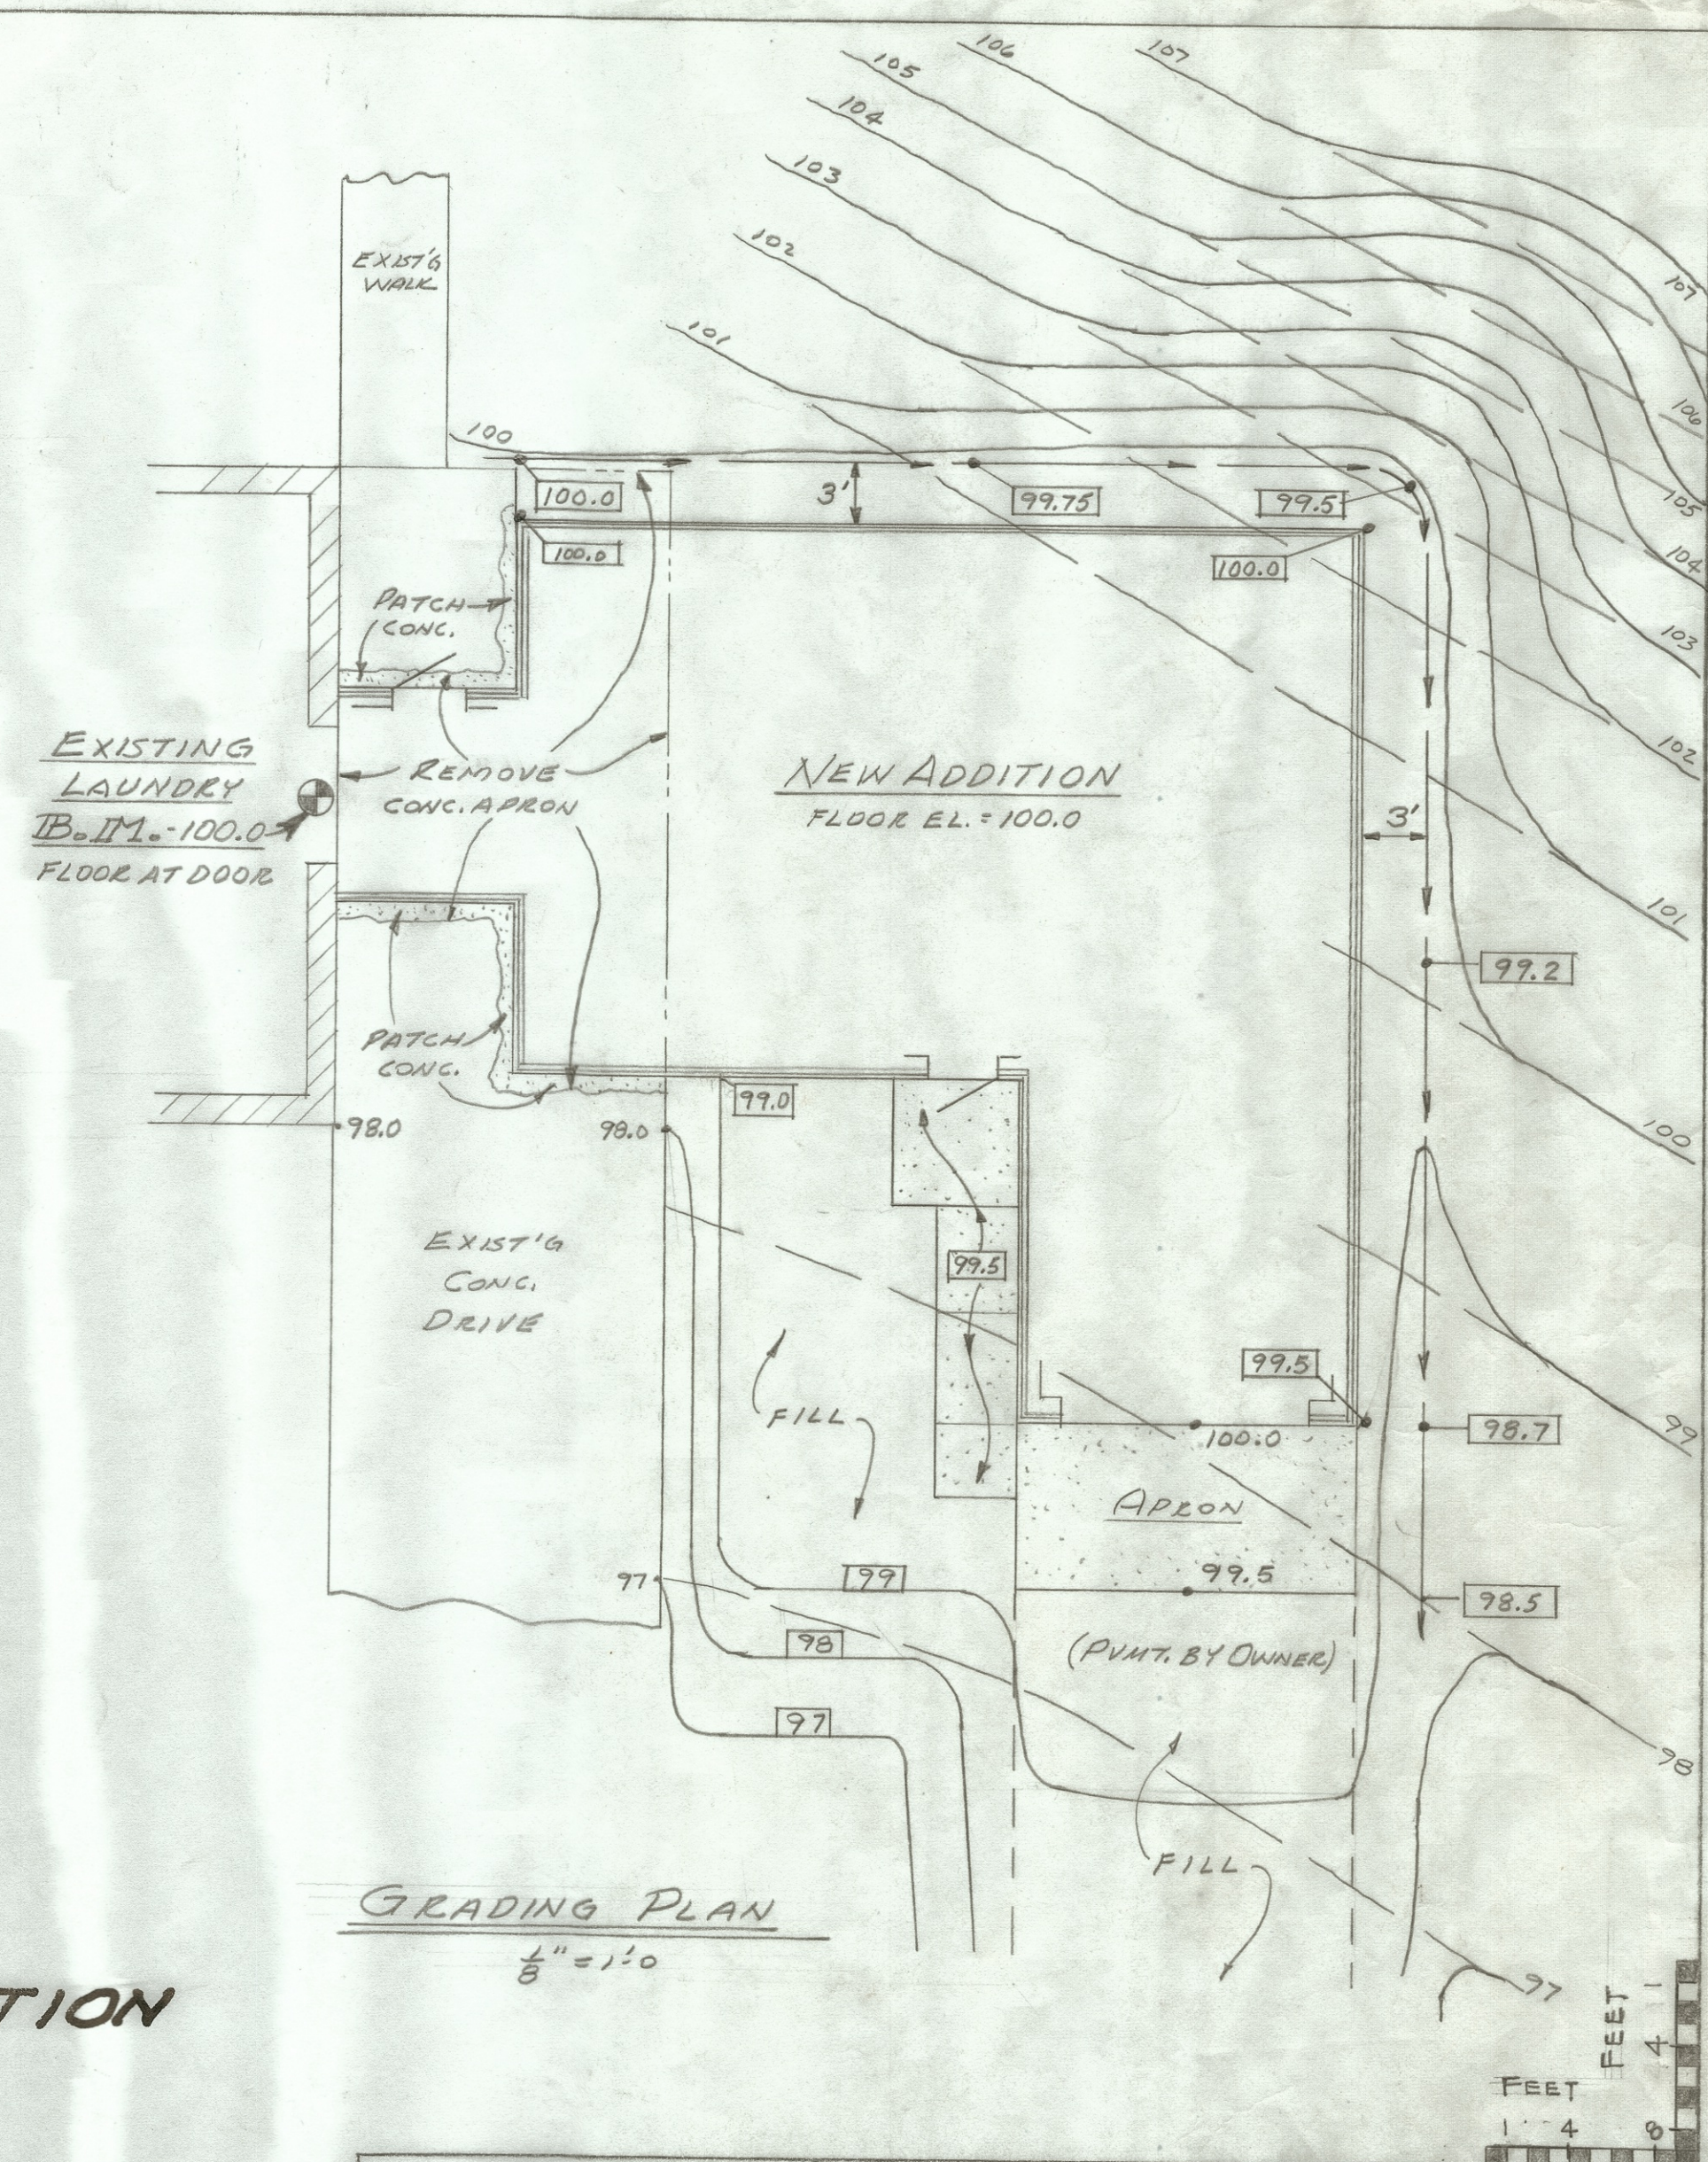





.. APPROVALS ..

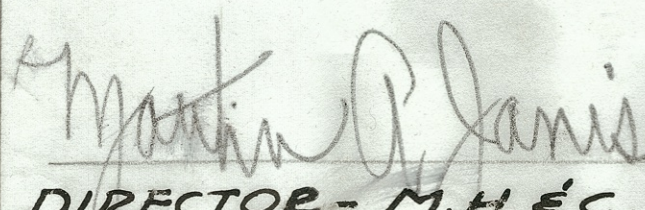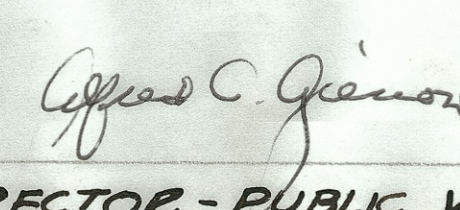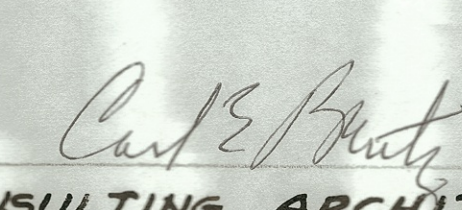DATE <u>5-9-67</u>	DATE <u>5/9/67</u>	DATE <u>5-9-67</u>
 DIRECTOR - M.H. & C.	 DIRECTOR - PUBLIC WORKS	 CONSULTING ARCHITECT






INDEX TO DRAWINGS -

- 1- PLOT PLAN, FLOOR PLAN, EAST ELEVATION
- 2- NORTH & WEST ELEVS., SECTIONS, FLASHING DETAILS
- 3- SECTIONS, ROOF DETAILS
- 4- SECTIONS, DOOR & WINDOW DETAILS
- 5- ROOF FRAMING; HEATING & VENTILATING
- 6- SCALE PIT; PLUMBING
- 7- OVERHEAD DOORS; ELECTRICAL

C-1645-E

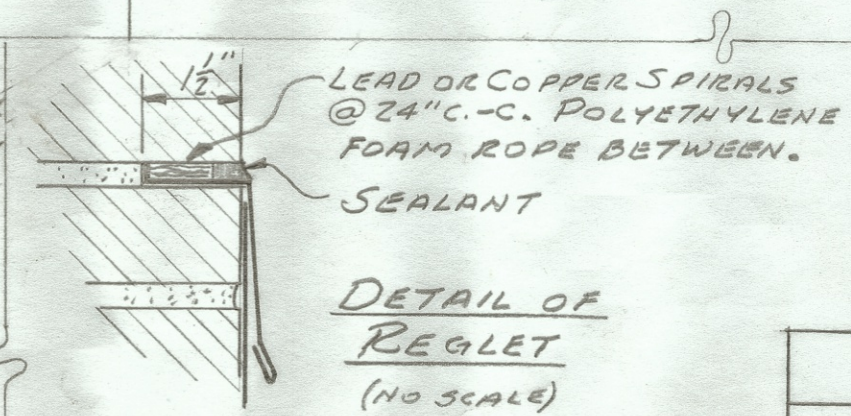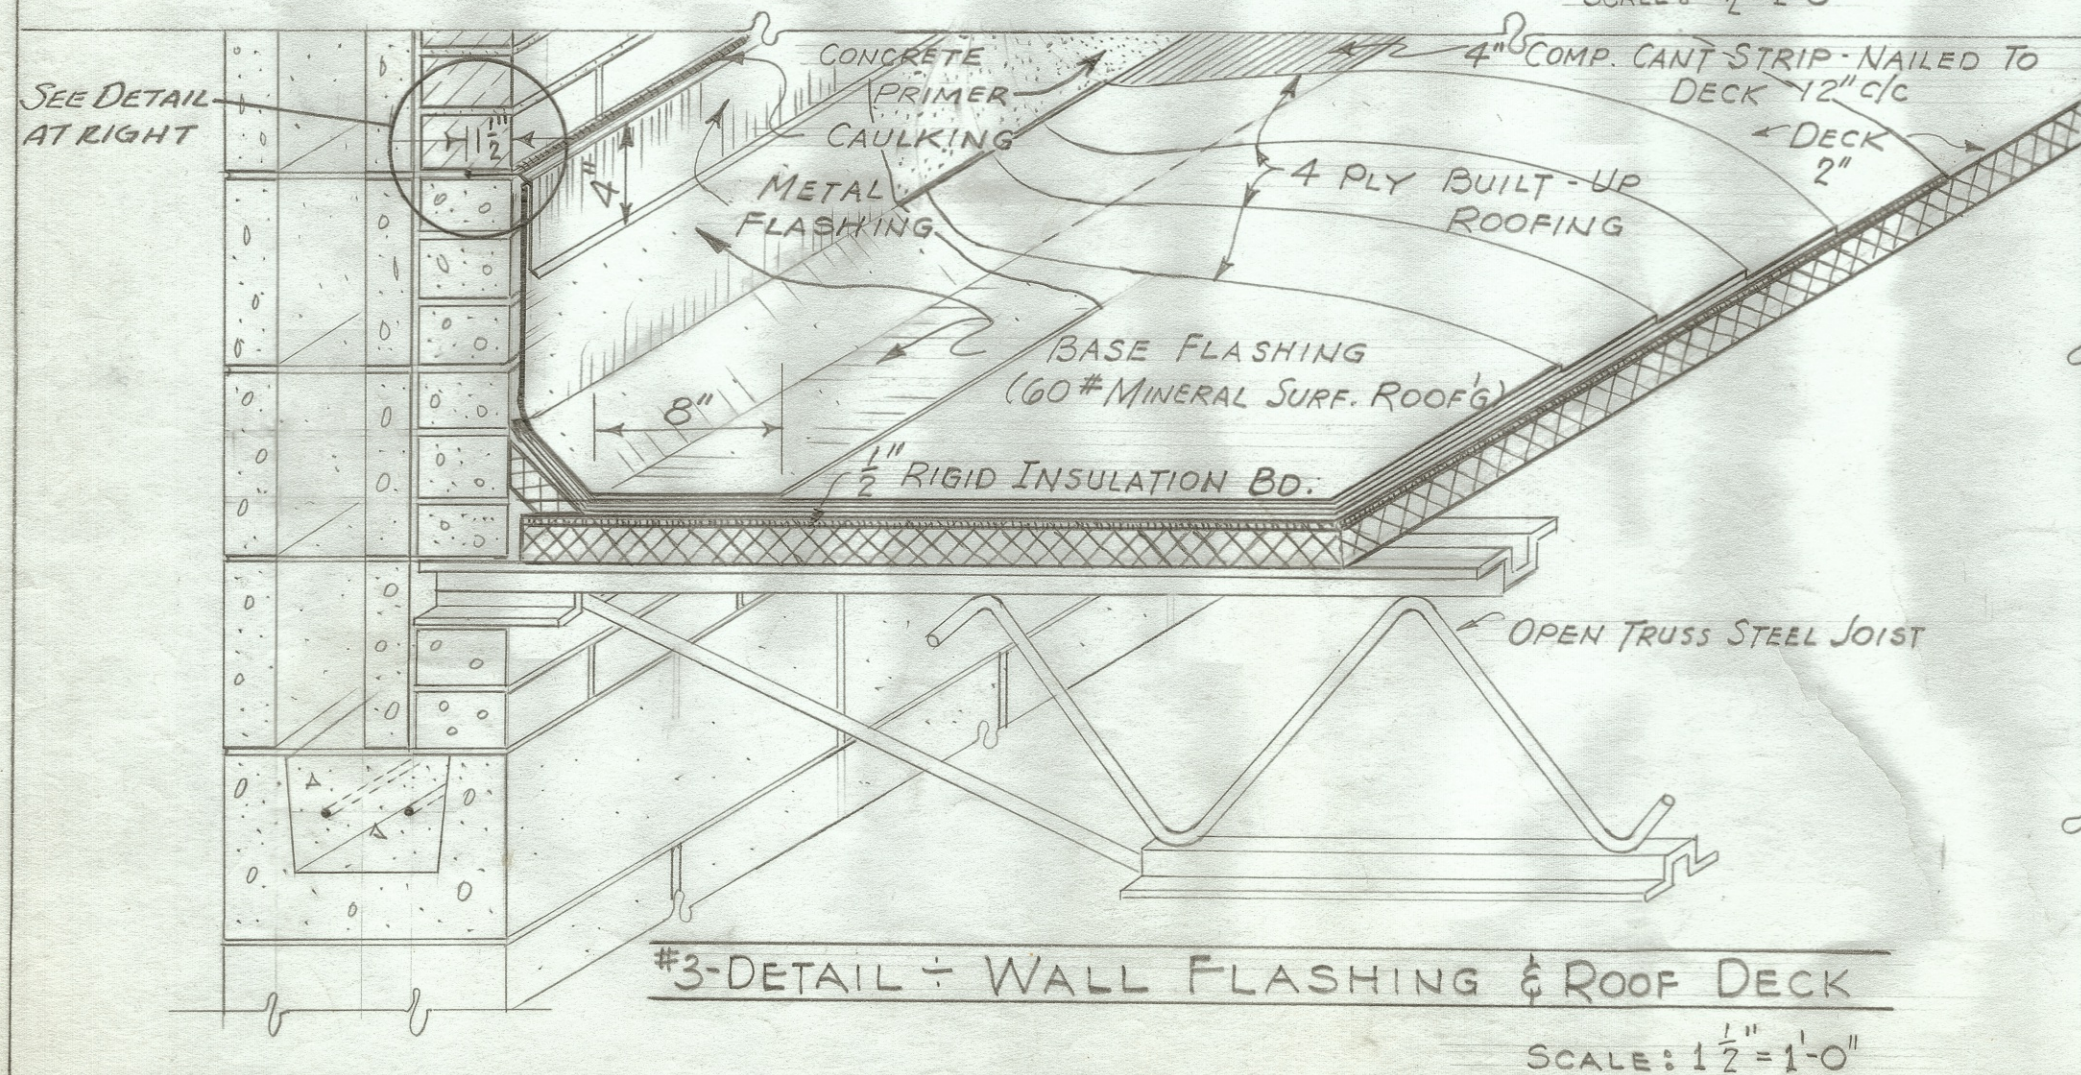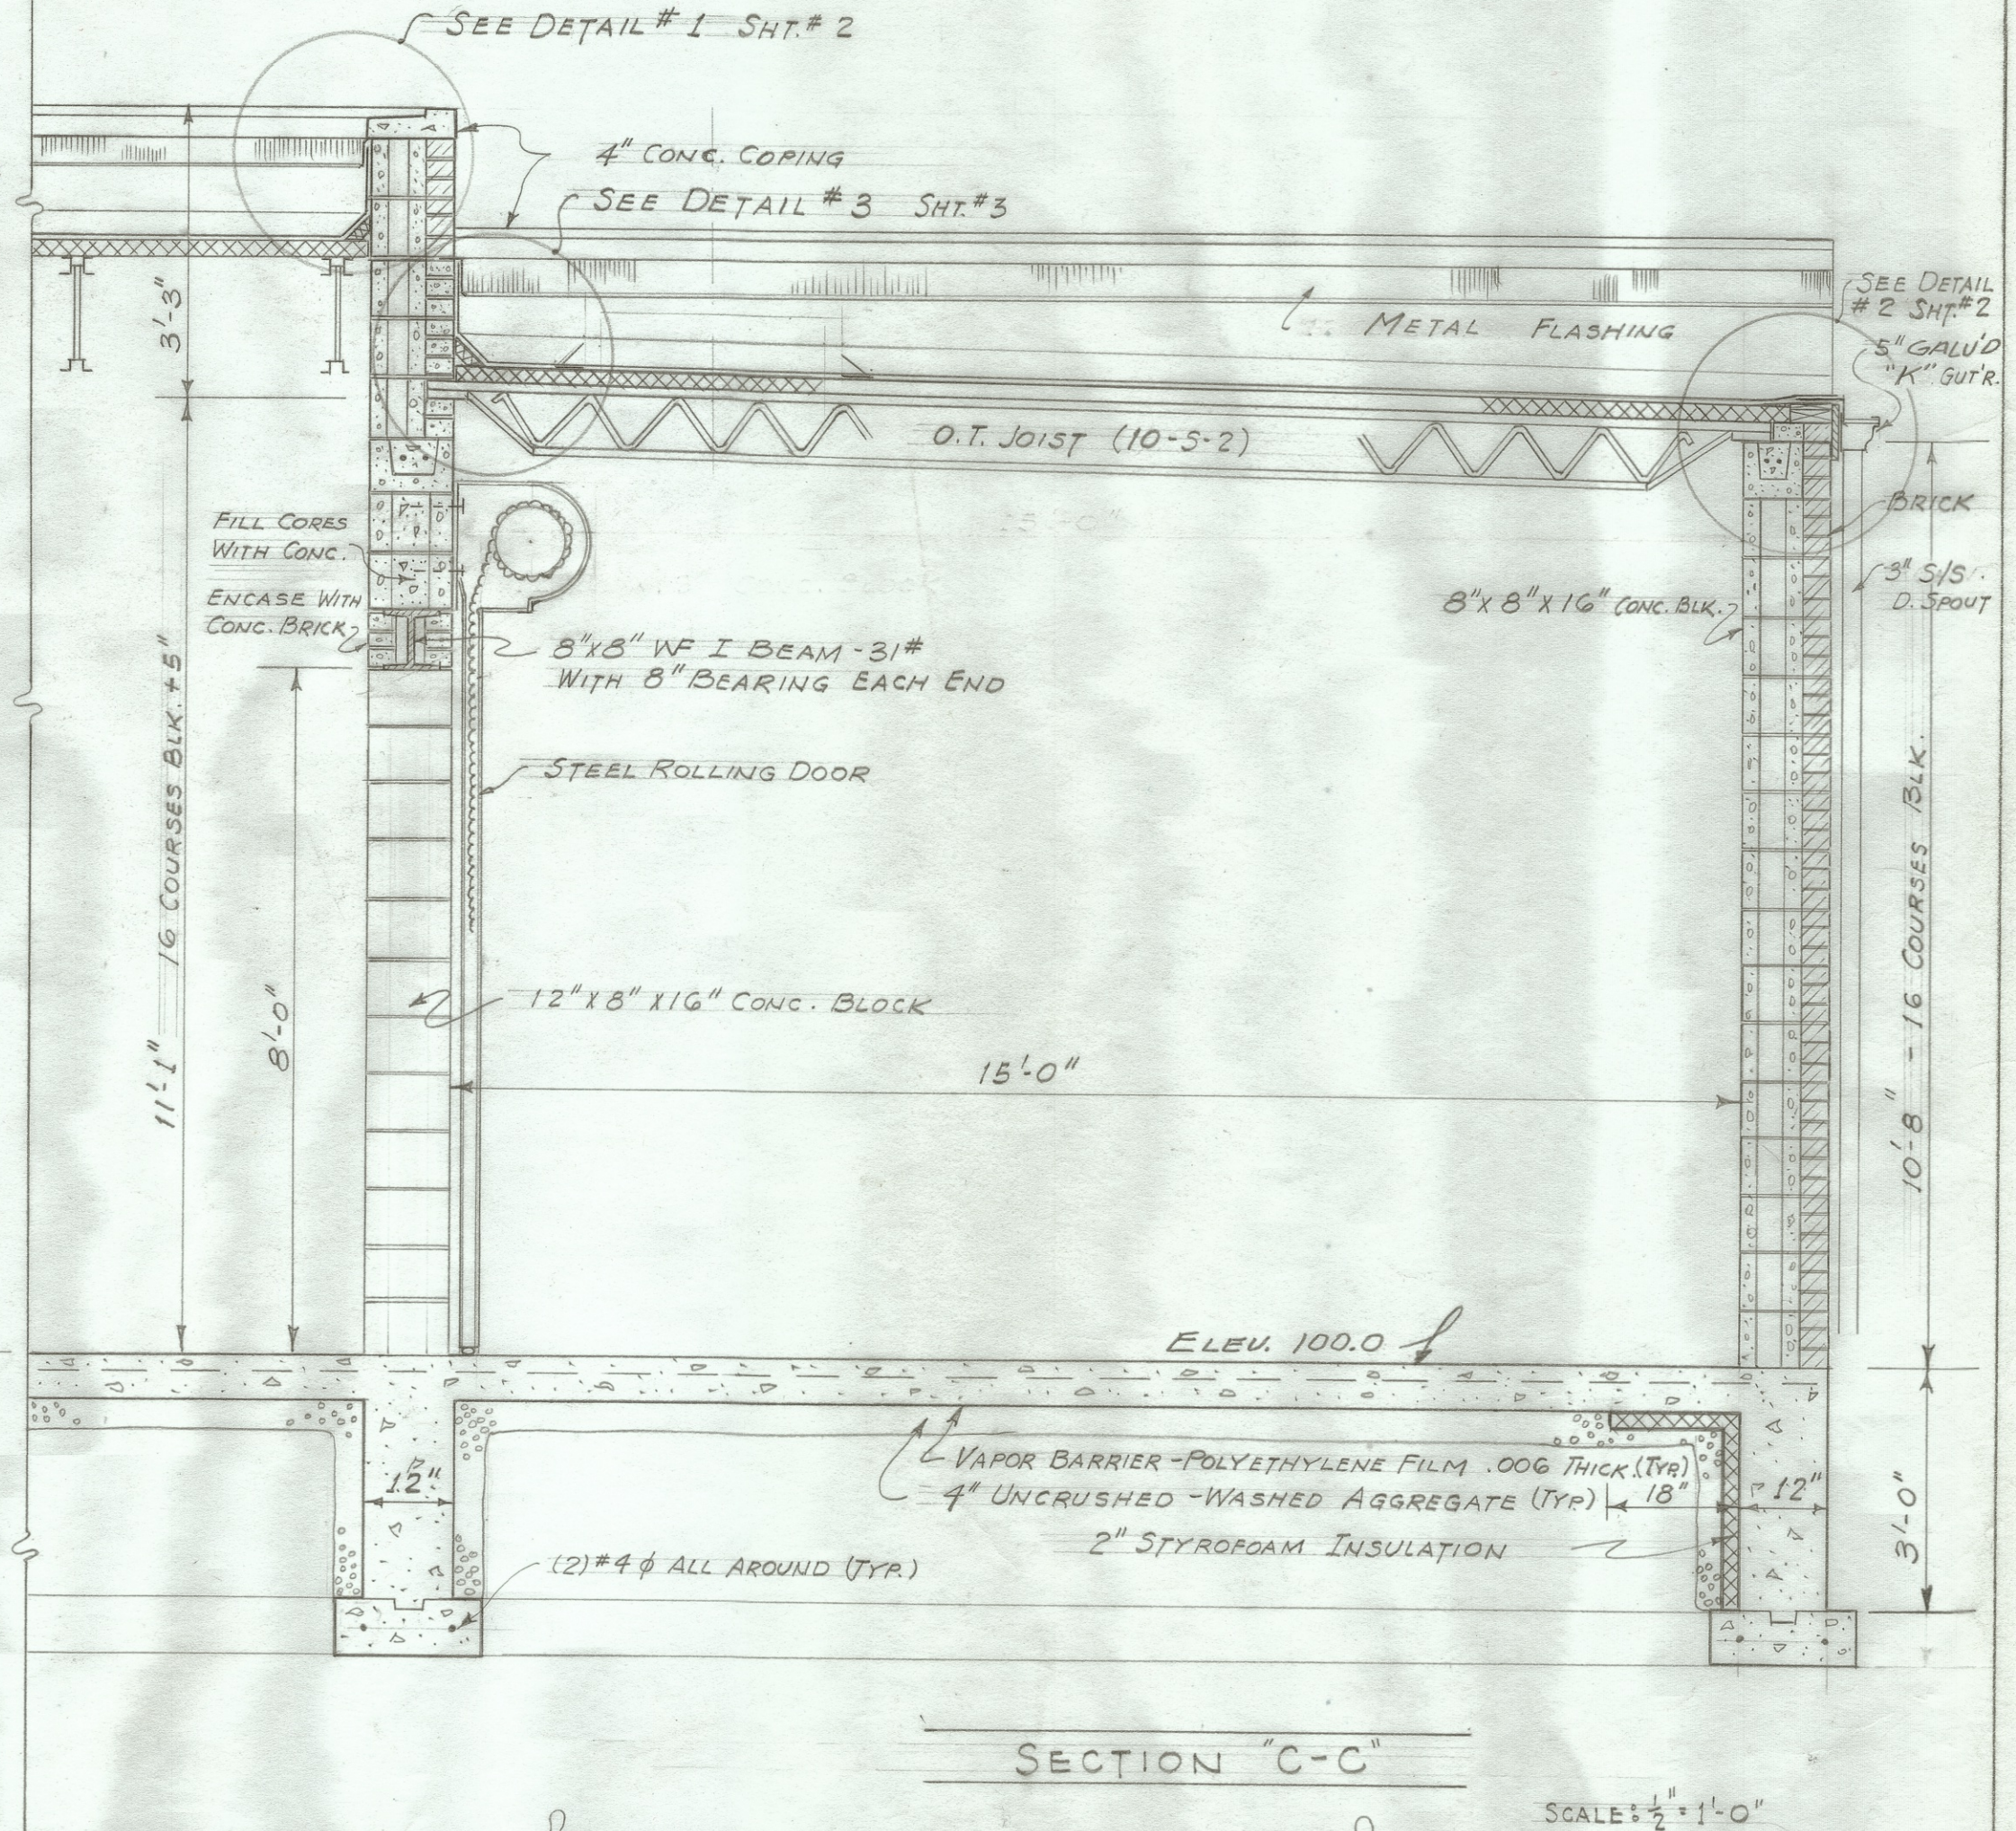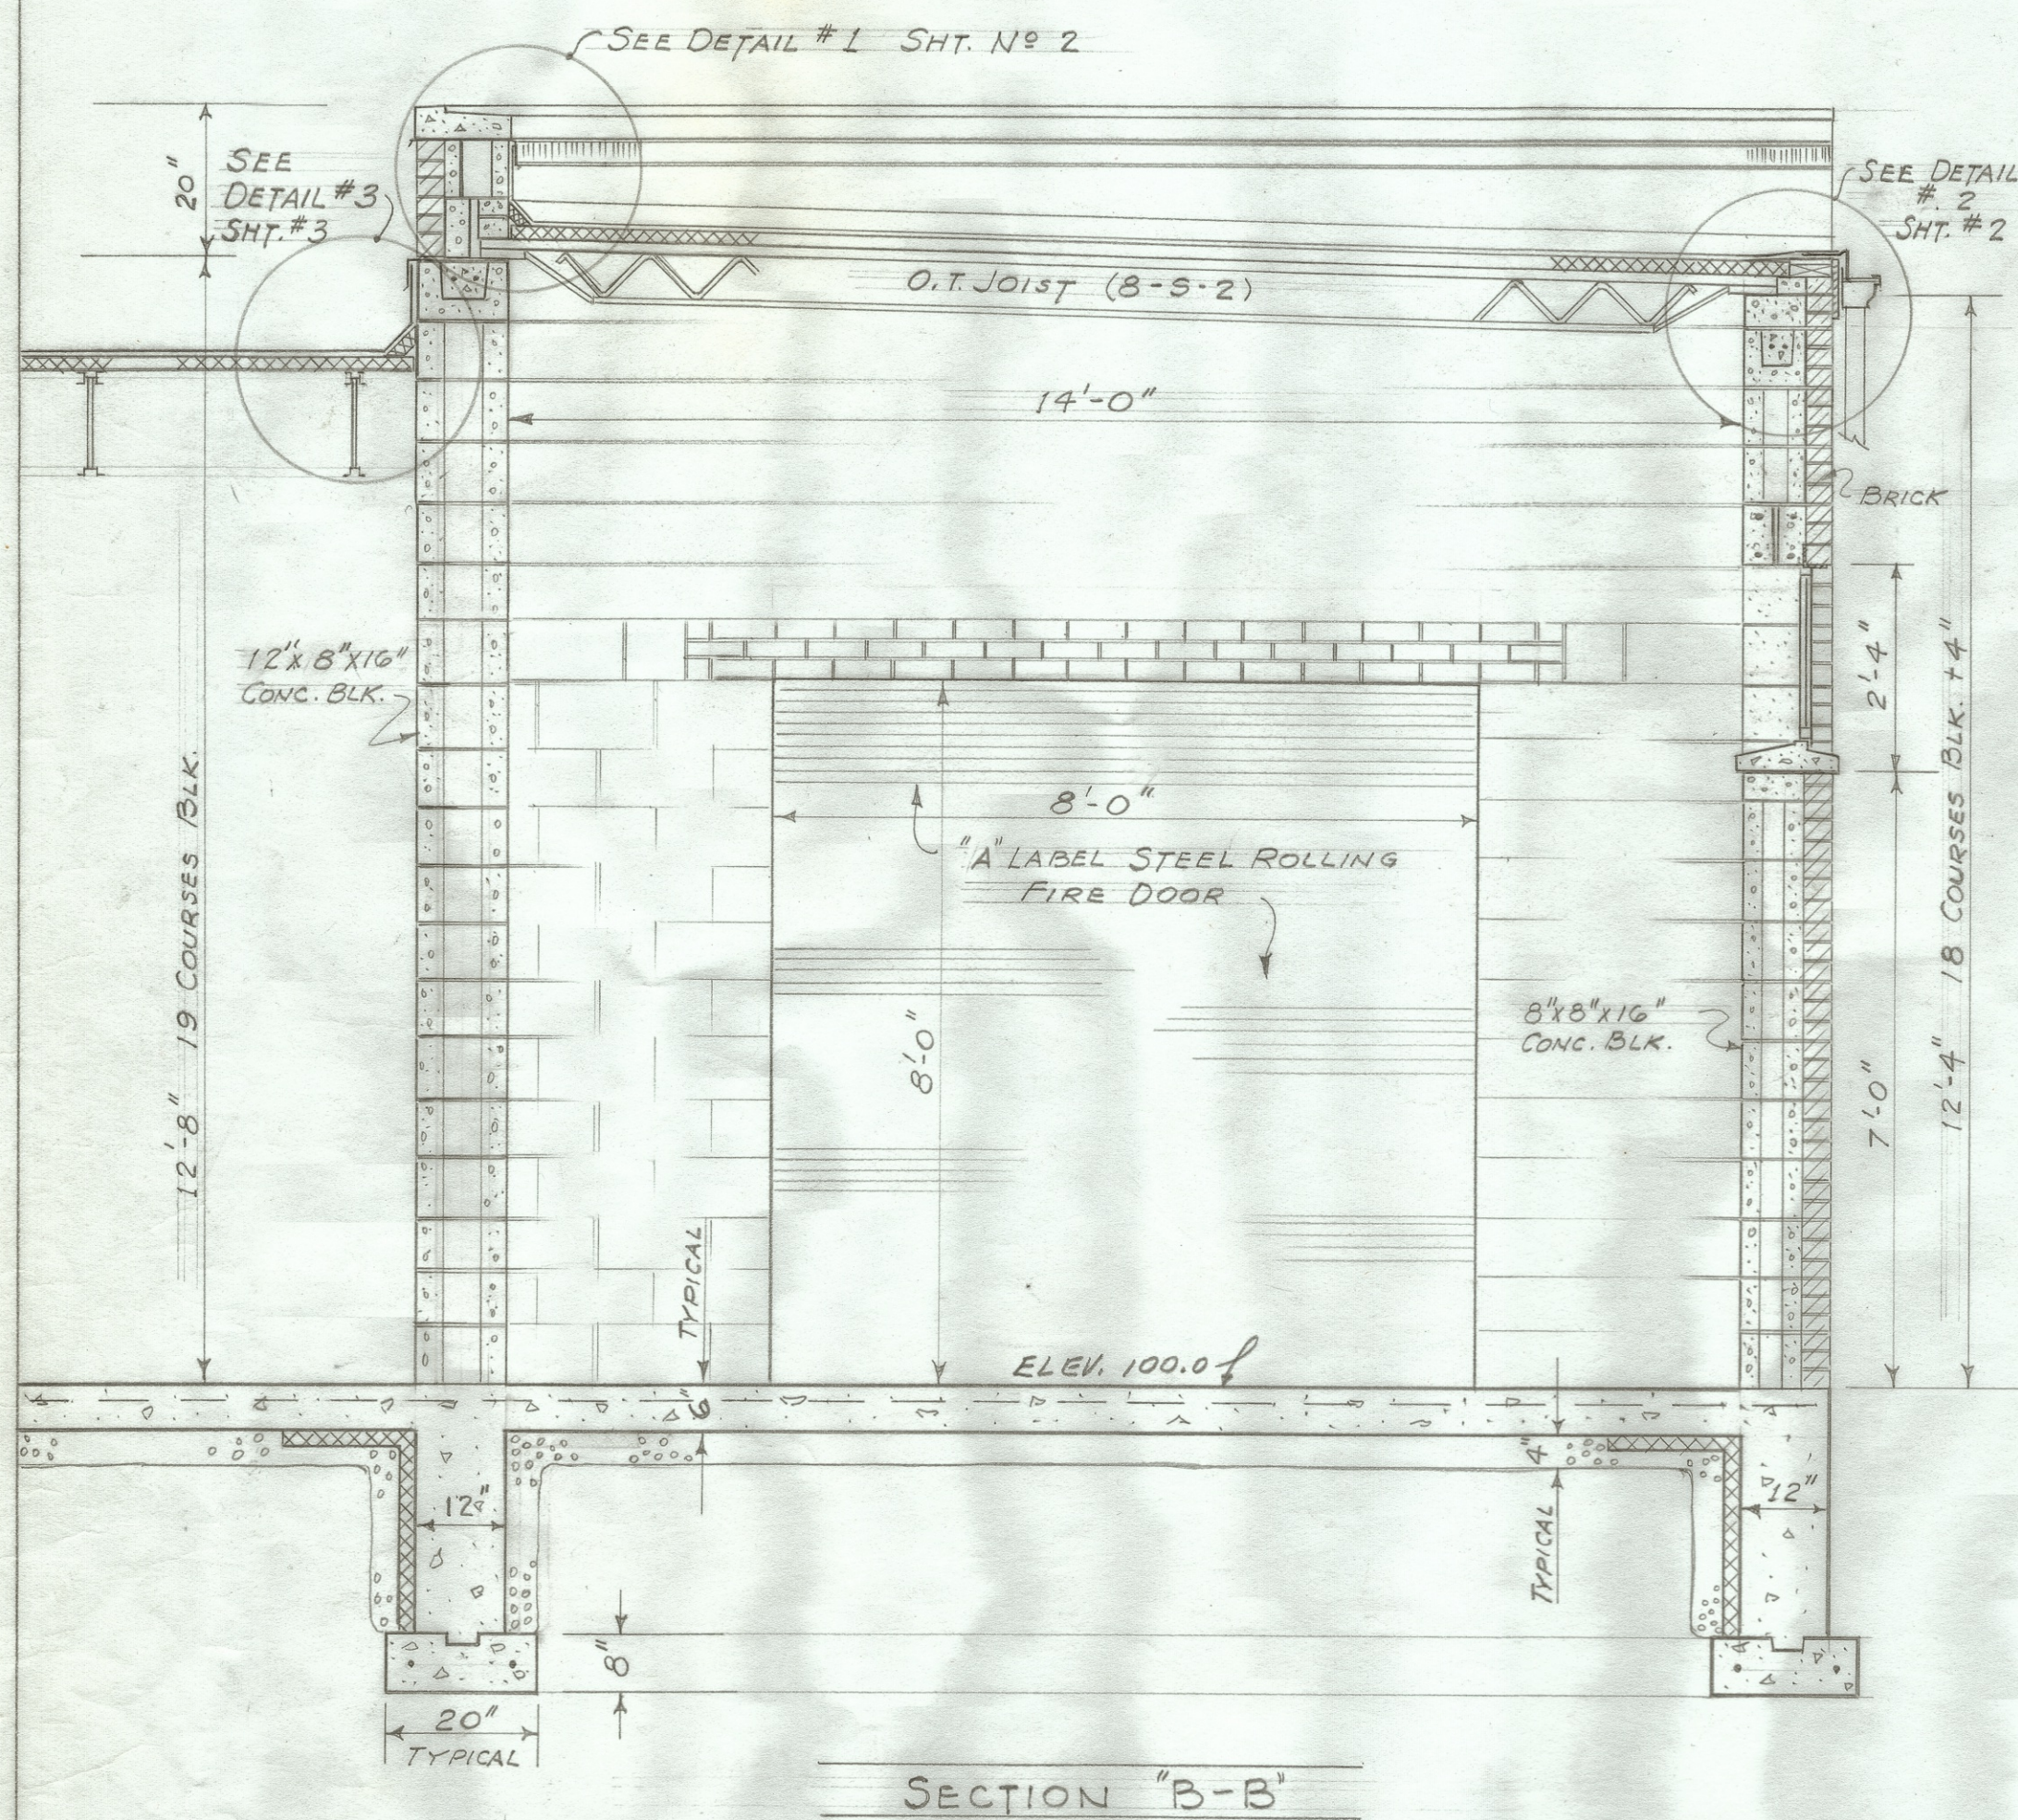

SECTIONS, ROOF DETAILS			
ADDITION TO LAUNDRY			
MASSILLON STATE HOSPITAL - - MASSILLON, O.			
APPROVED _____	19__	PREPARED FOR	
DIRECTOR-MENT. HYG. & CORR.		STATE OF OHIO	
APPROVED _____	19__	DEPARTMENT OF PUBLIC WORKS	
APPROVED _____		PREPARED BY	
CONSULTING ARCHITECT		DEPARTMENT OF MENTAL HYGIENE AND CORRECTION	
APPROVED _____	19__	ENGINEER	DRAWN <u>W. Meyer</u> DATE <u>5/1/67</u>
DIRECTOR OF PUBLIC WORKS		SECTION CHIEF	CHECKED <u>✓</u> DATE _____
		SCALE <u>NOTED</u>	DRAWING NO. <u>C-1645-E</u>
			SHEET <u>3</u> OF <u>7</u>

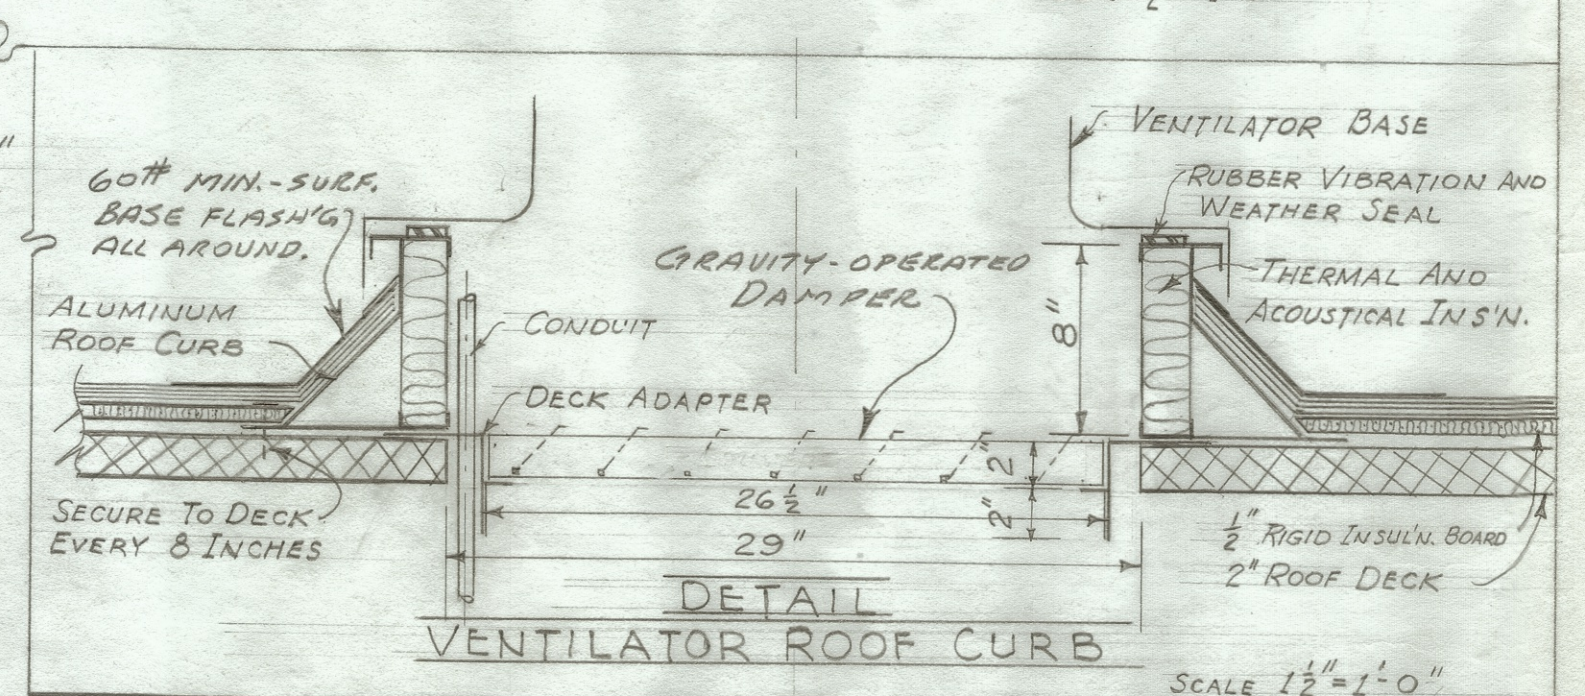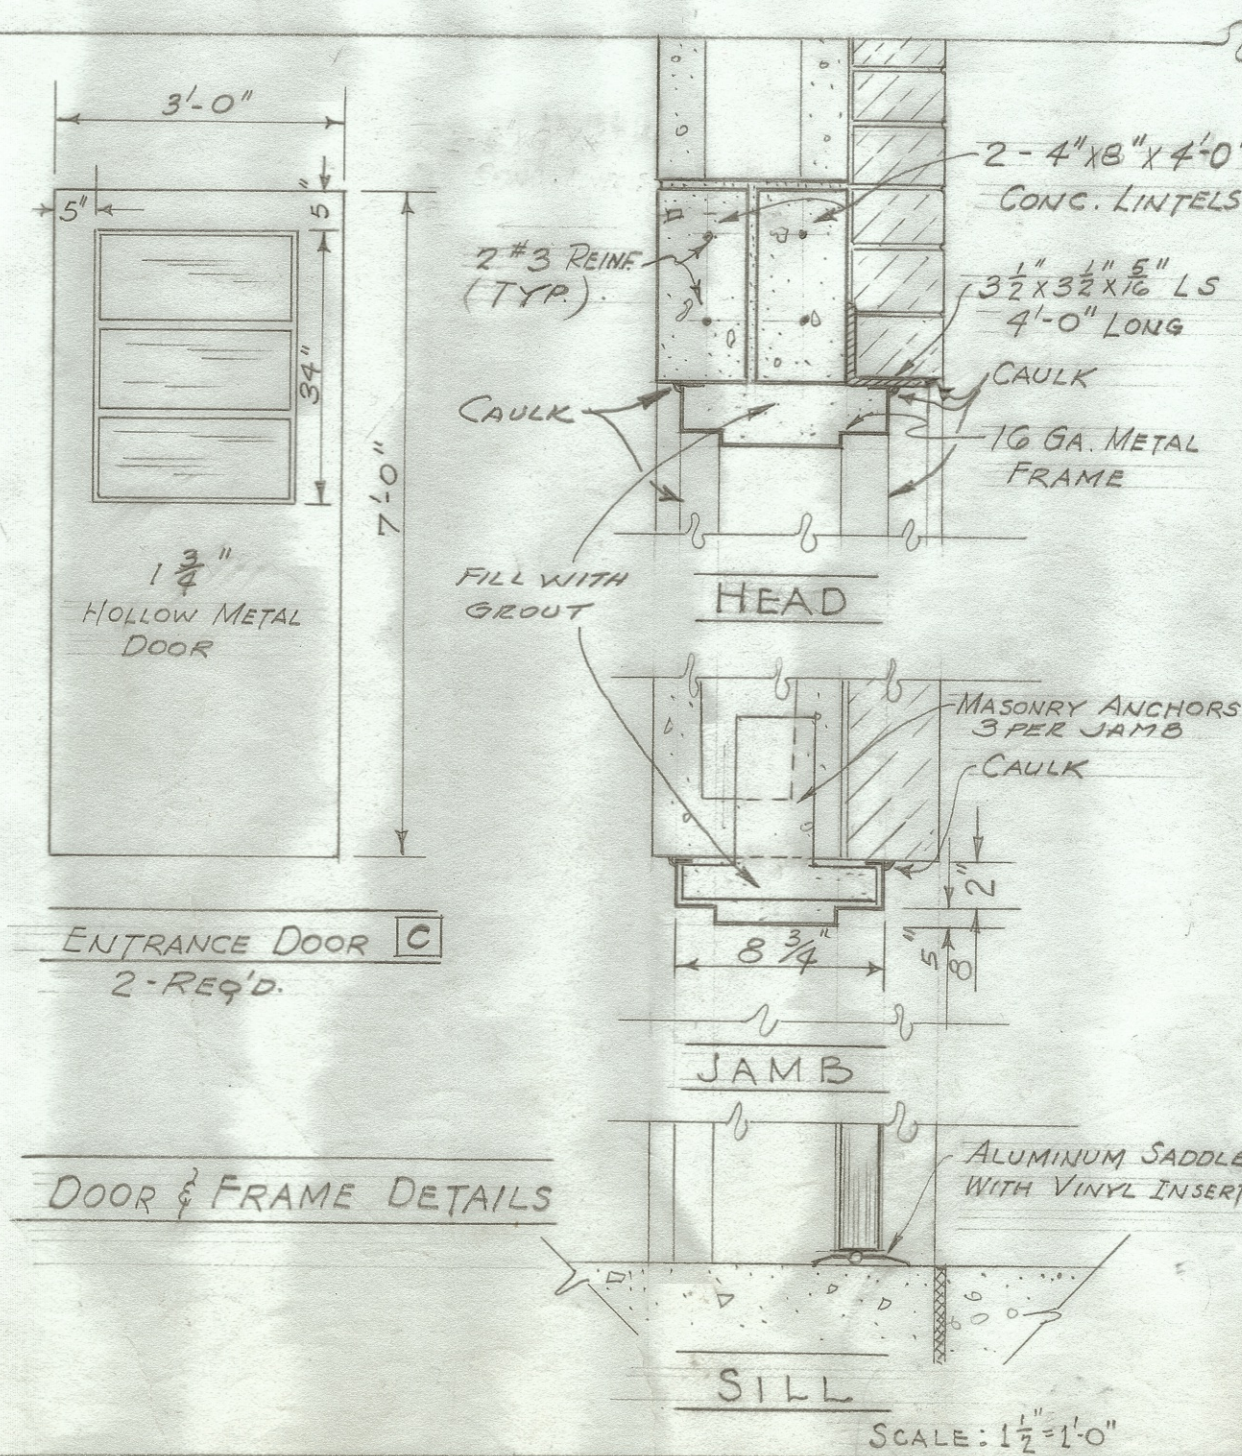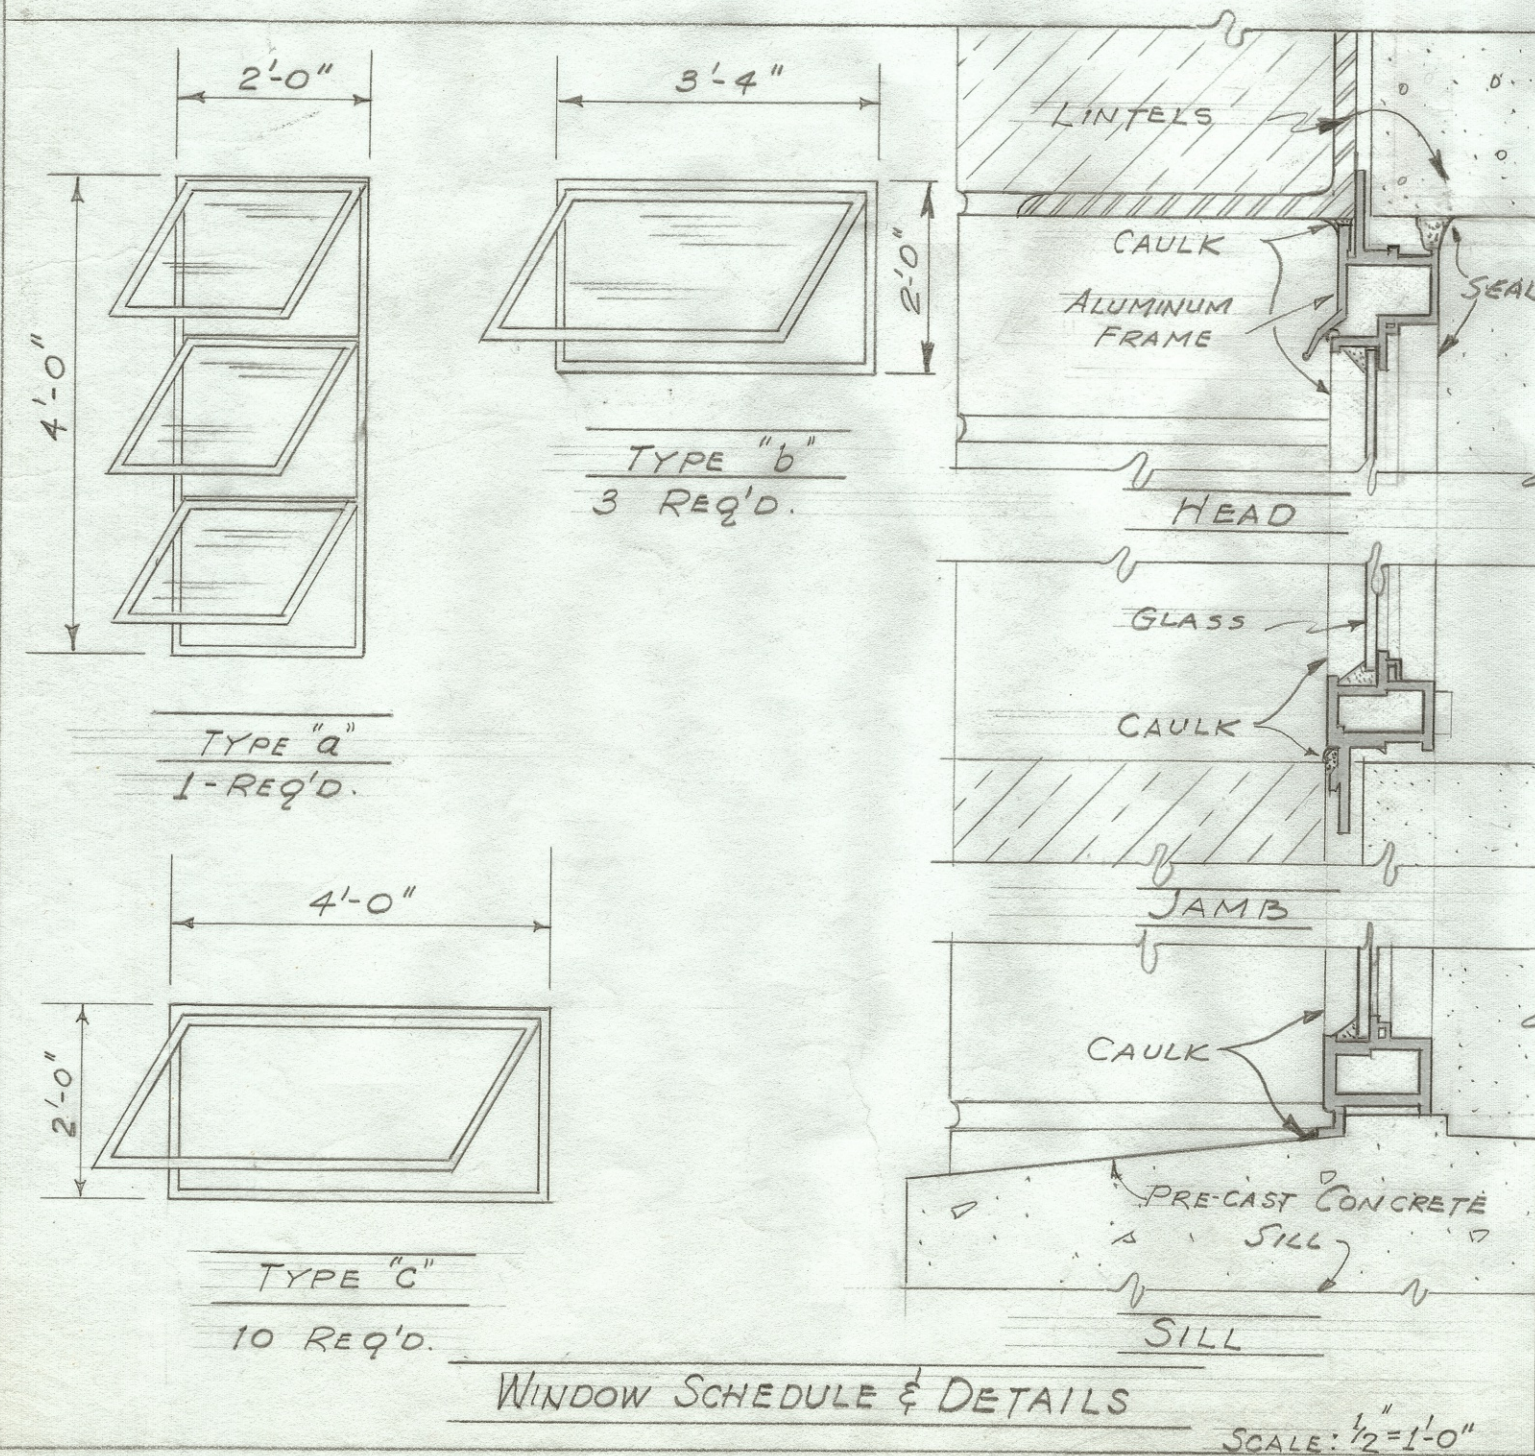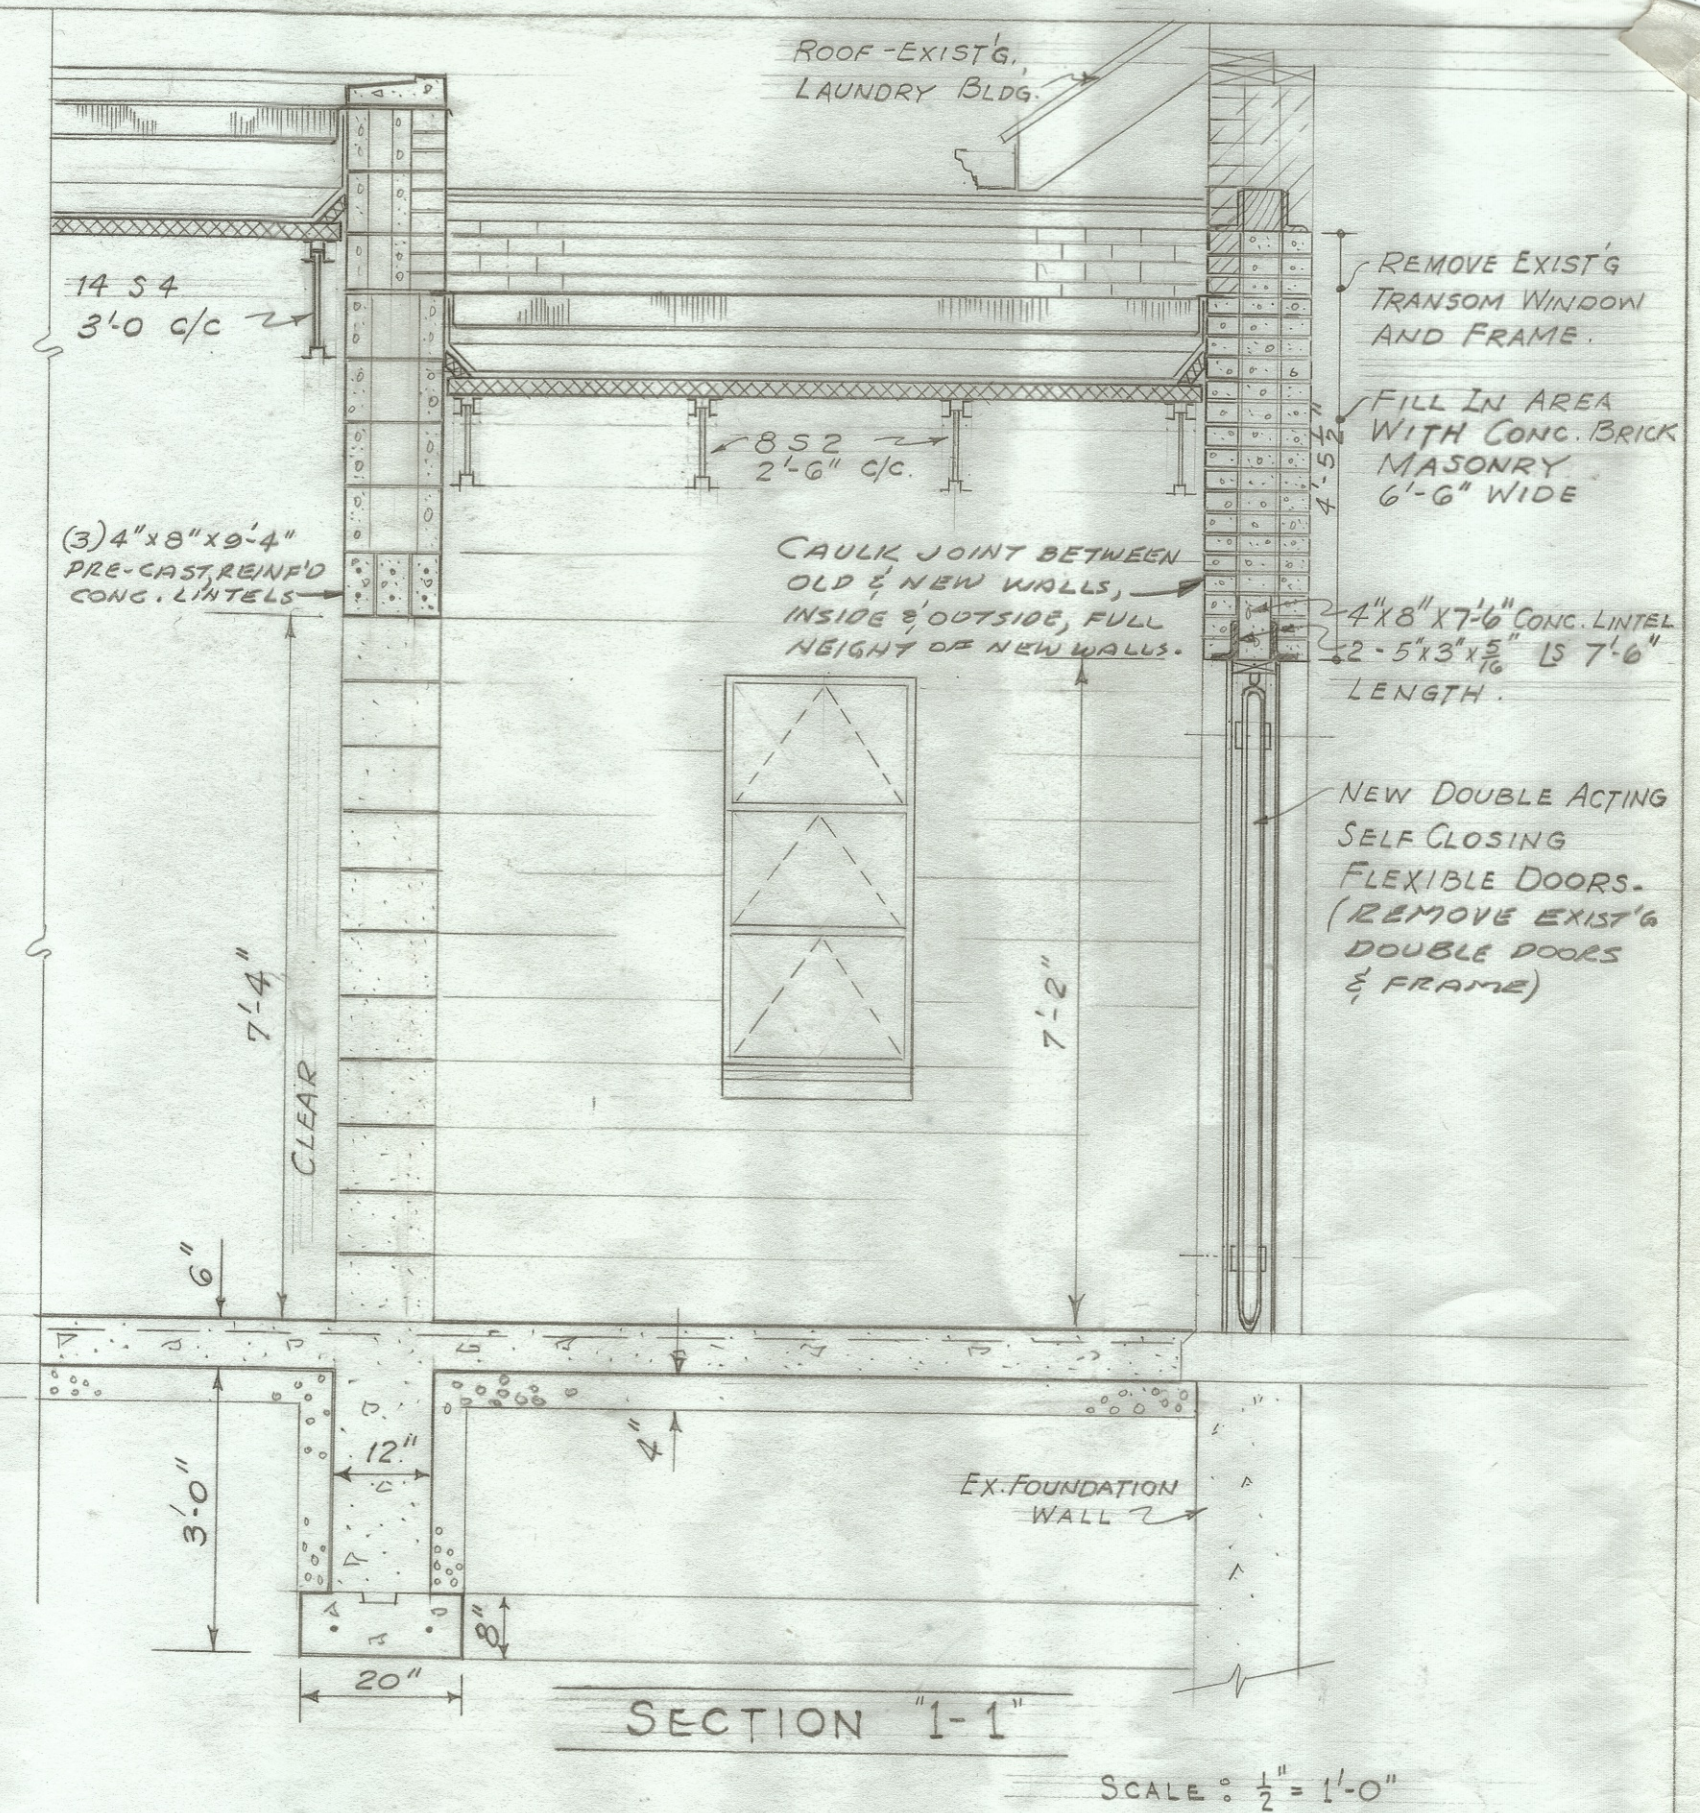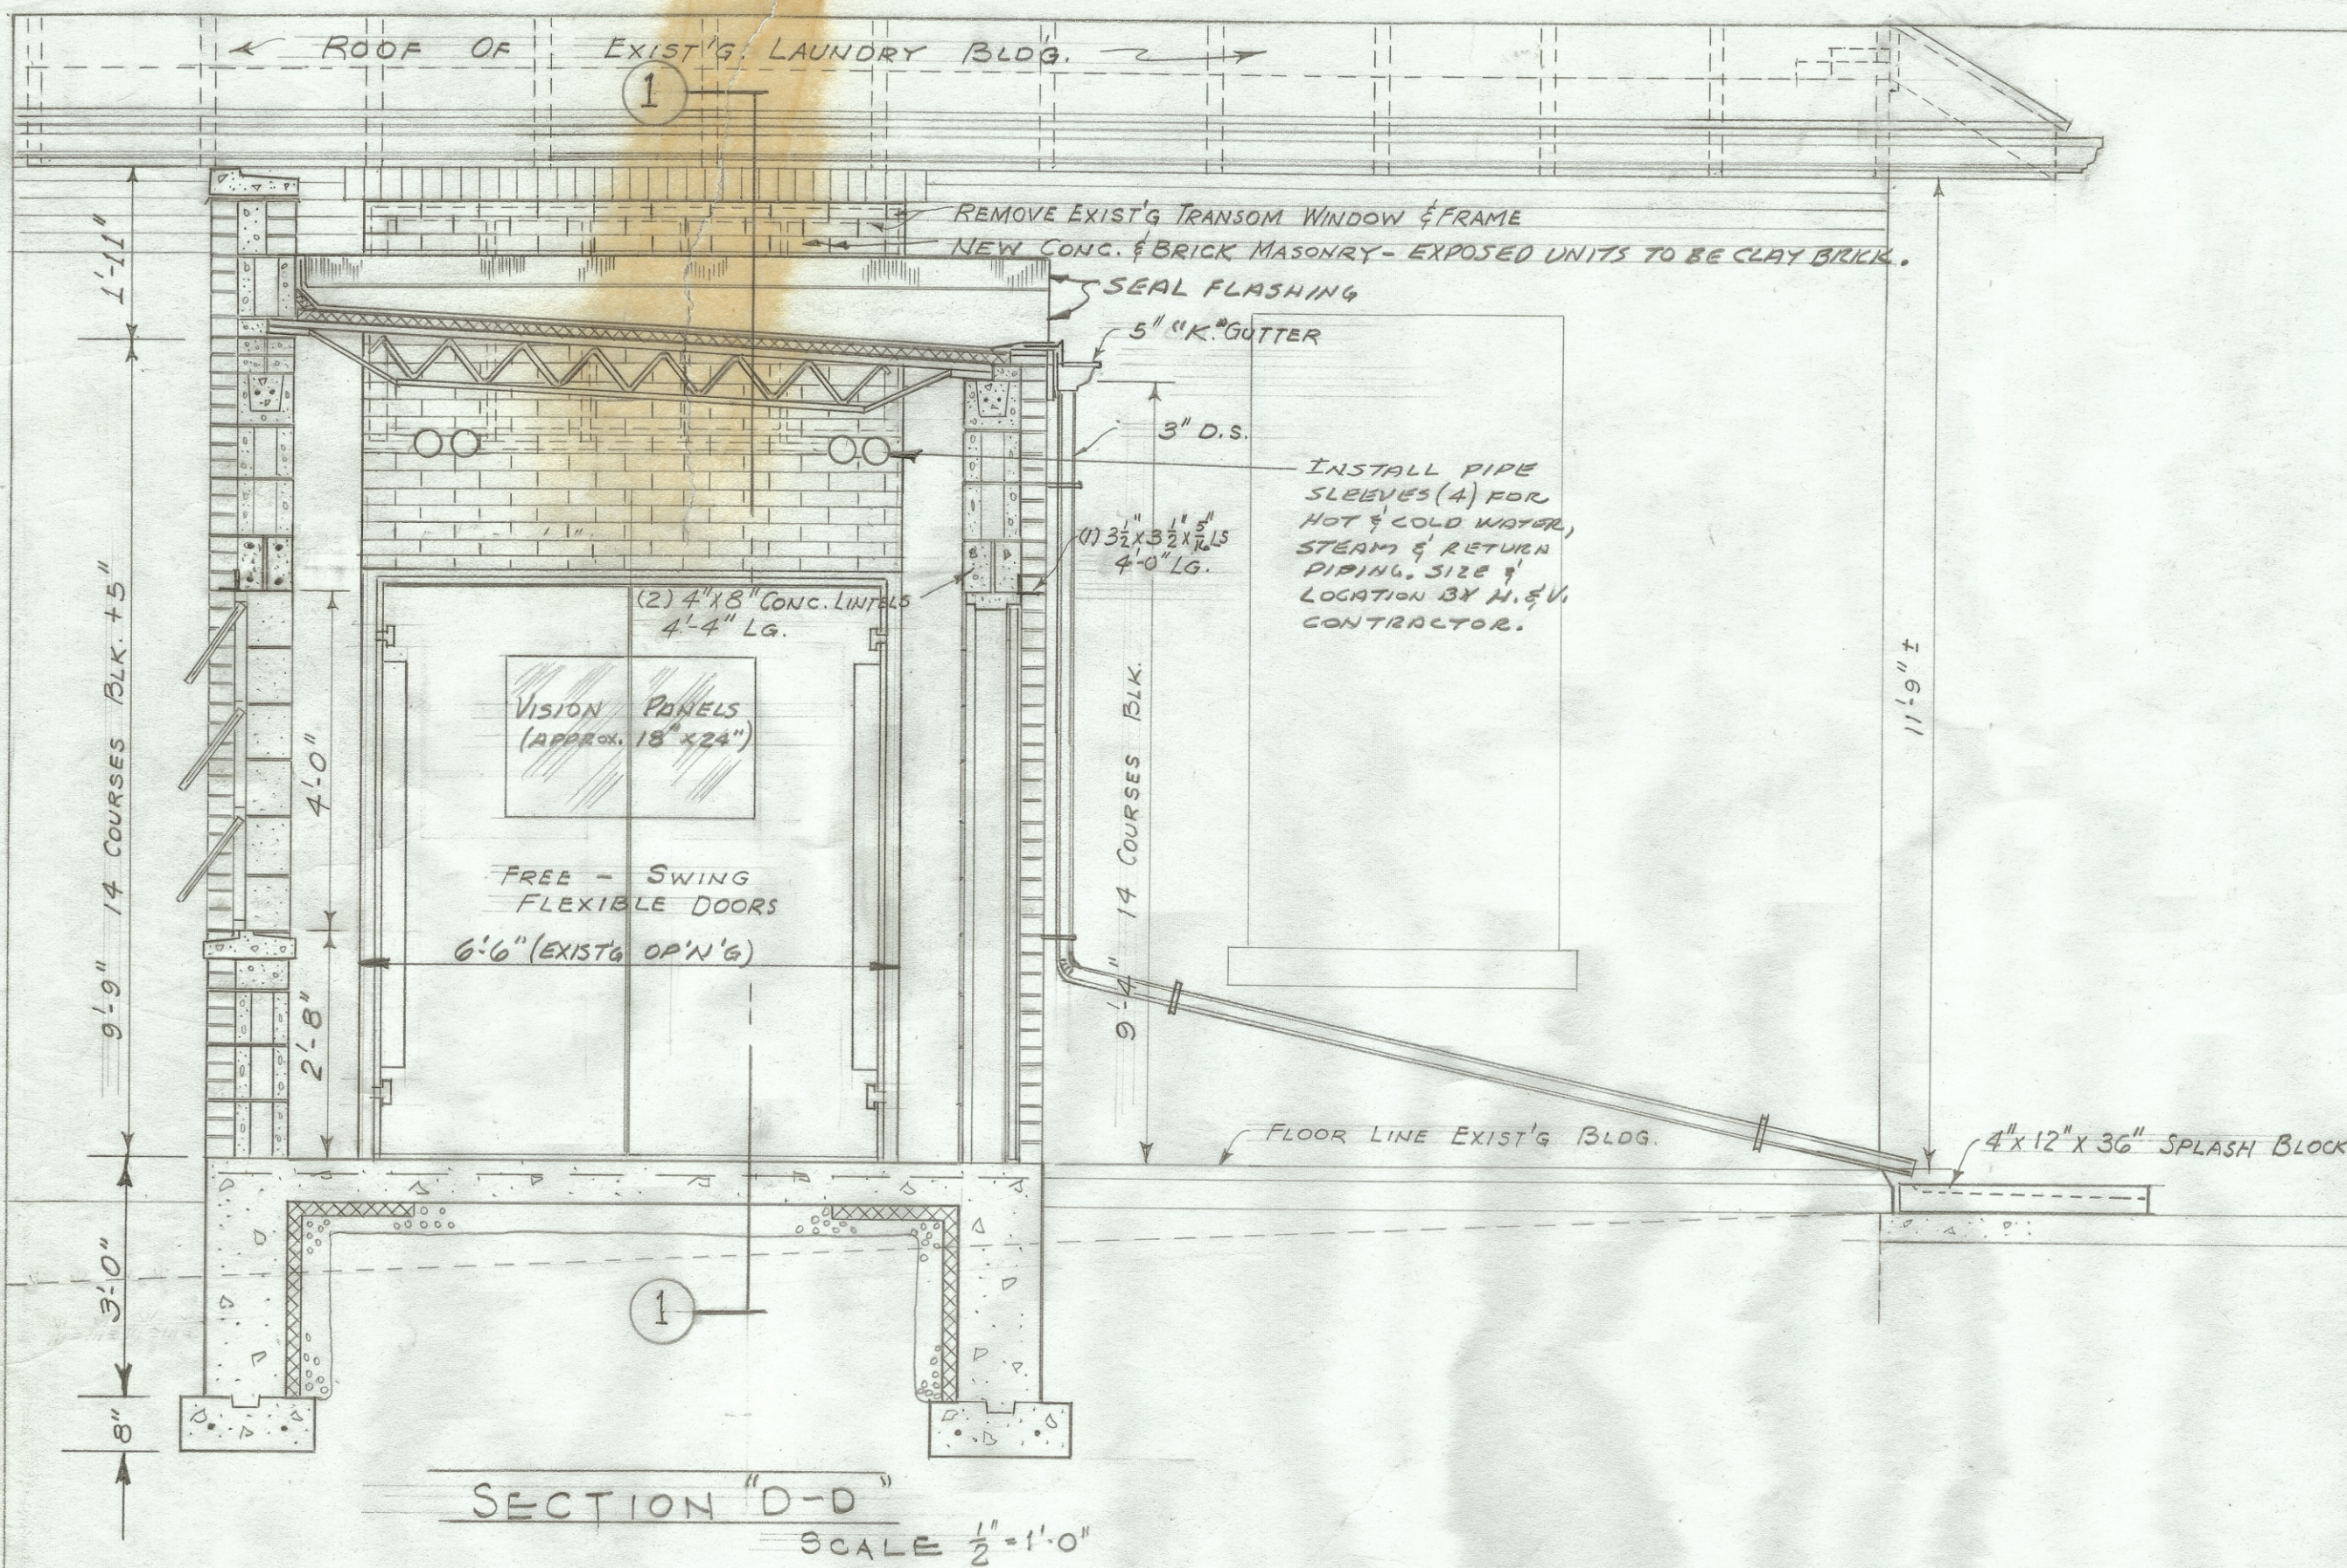


SECTIONS, DOOR & WINDOW DETAILS

ADDITION TO LAUNDRY

MASSILLON STATE HOSPITAL - - MASSILLON, O.


APPROVED	19	PREPARED FOR	STATE OF OHIO
DIRECTOR-MENT. HYG. & CORR.		DEPARTMENT OF PUBLIC WORKS	
APPROVED	19	PREPARED BY	DEPARTMENT OF MENTAL HYGIENE AND CORRECTION
APPROVED	19		
CONSULTING ARCHITECT			
APPROVED	19	ENGINEER	
DIRECTOR OF PUBLIC WORKS		SECTION CHIEF	

DRAWN	DATE	DRAWING NO.
5/1/67	5/1/67	C-1645-E
CHECKED	DATE	SHEET
NOTED		4 OF 7

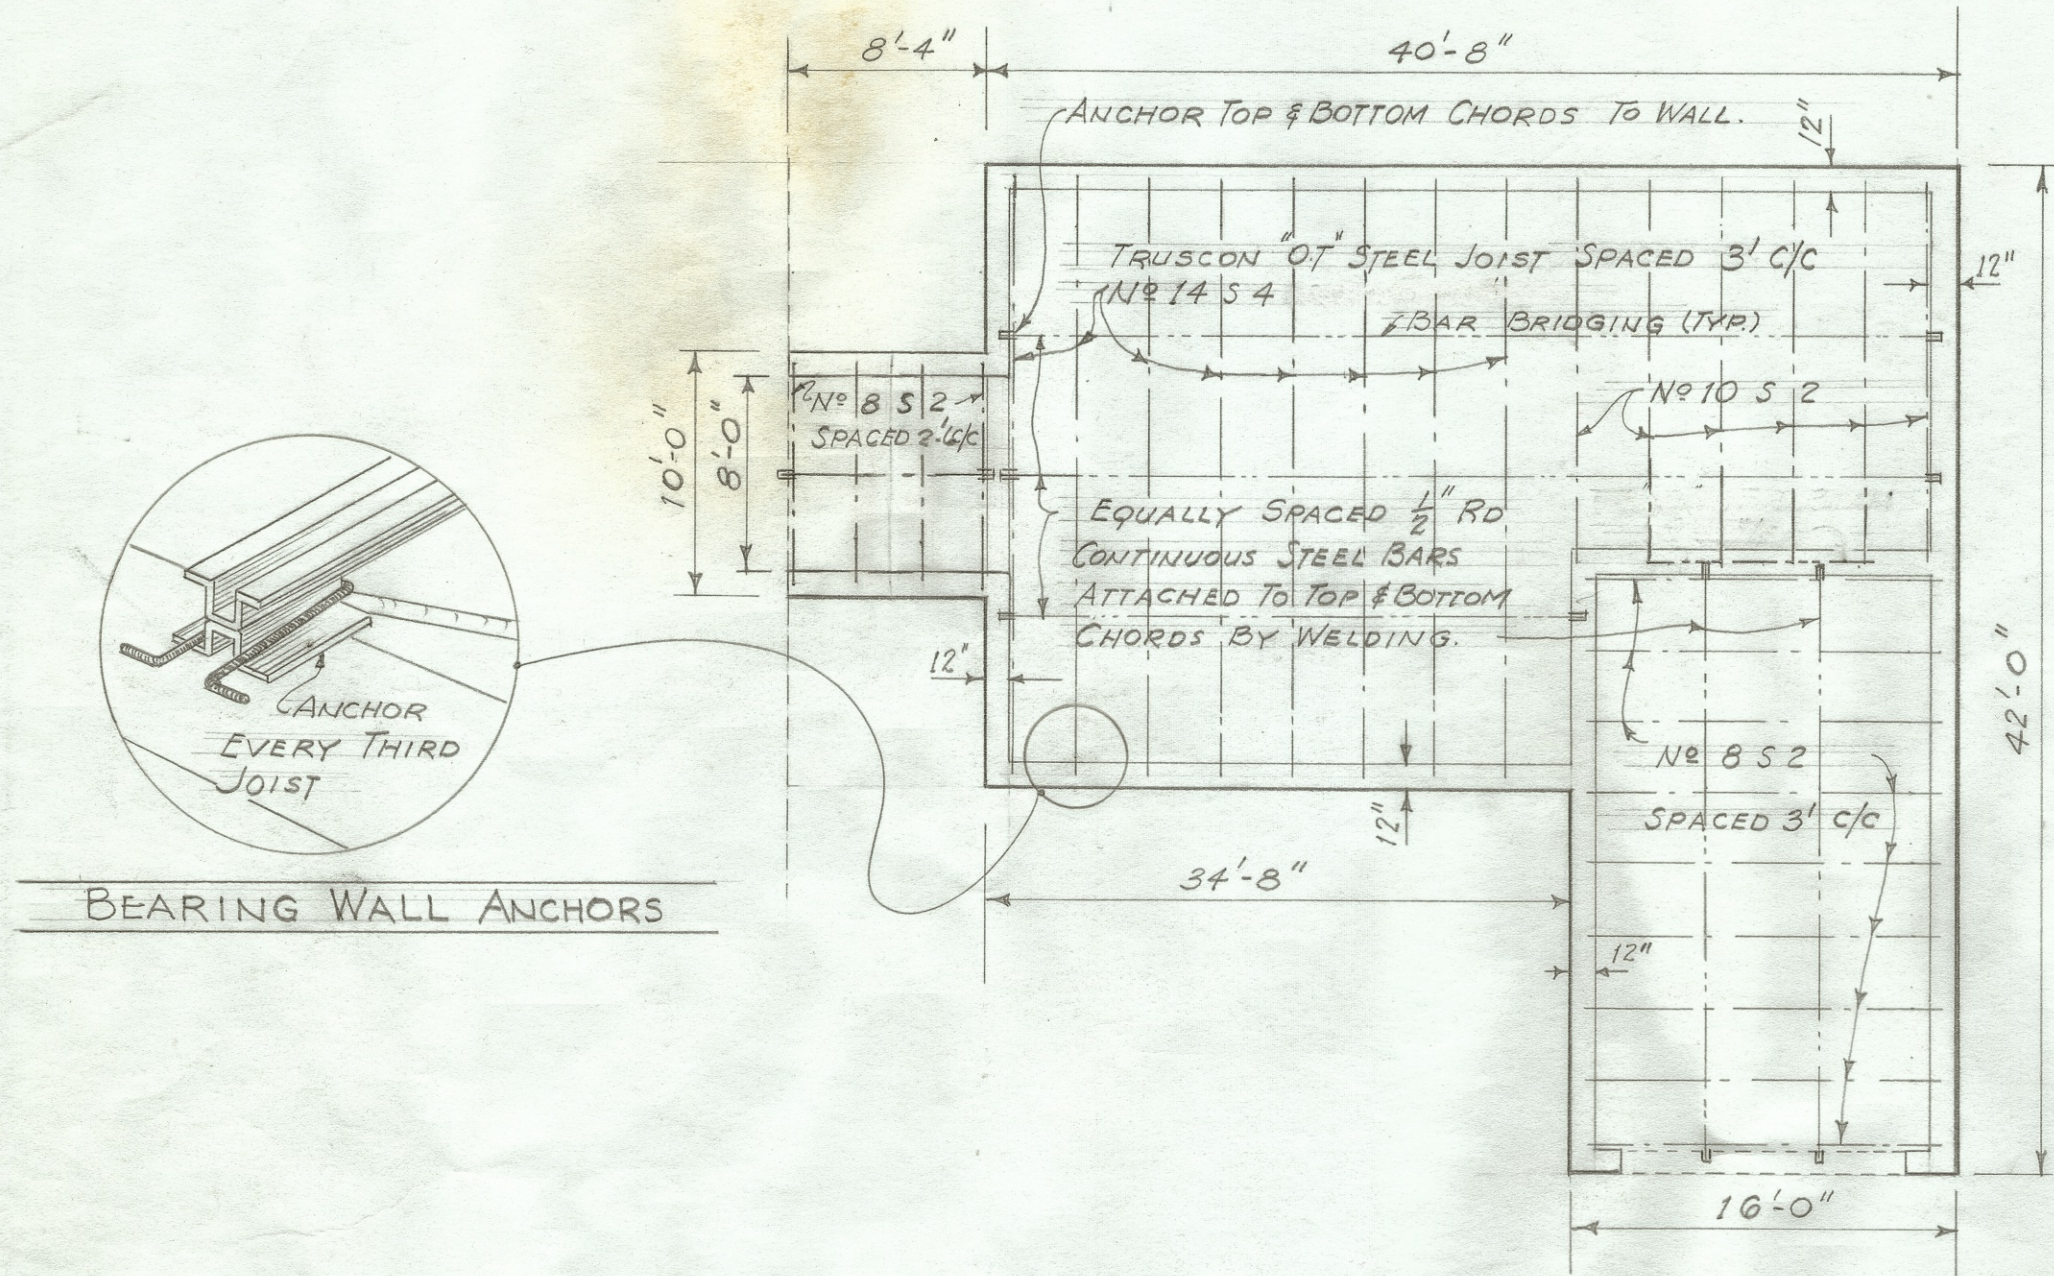


JOIST SPACING PLAN

SCALE: $\frac{1}{8}'' = 1'-0''$

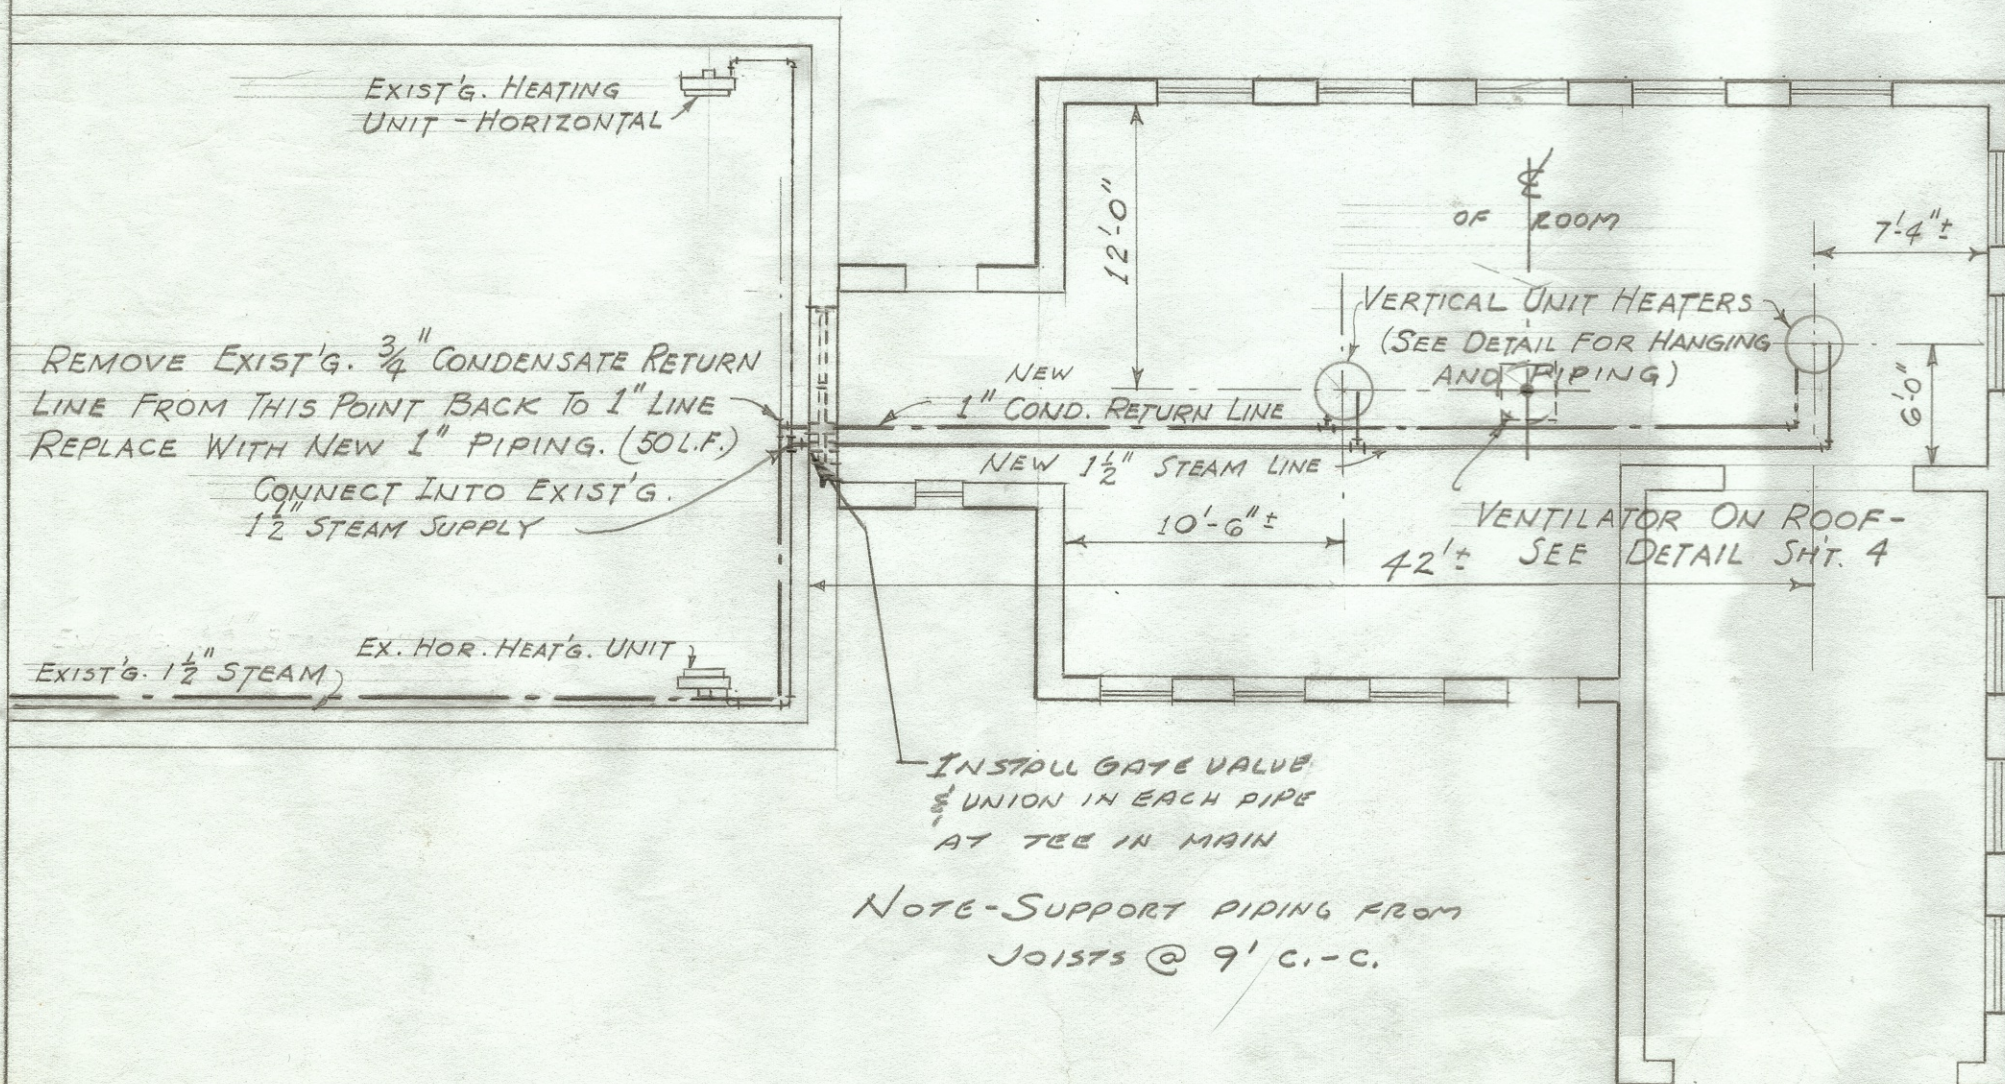

VENTILATING & HEATING LAYOUT PLAN

SCALE: $\frac{1}{8}'' = 1'-0''$

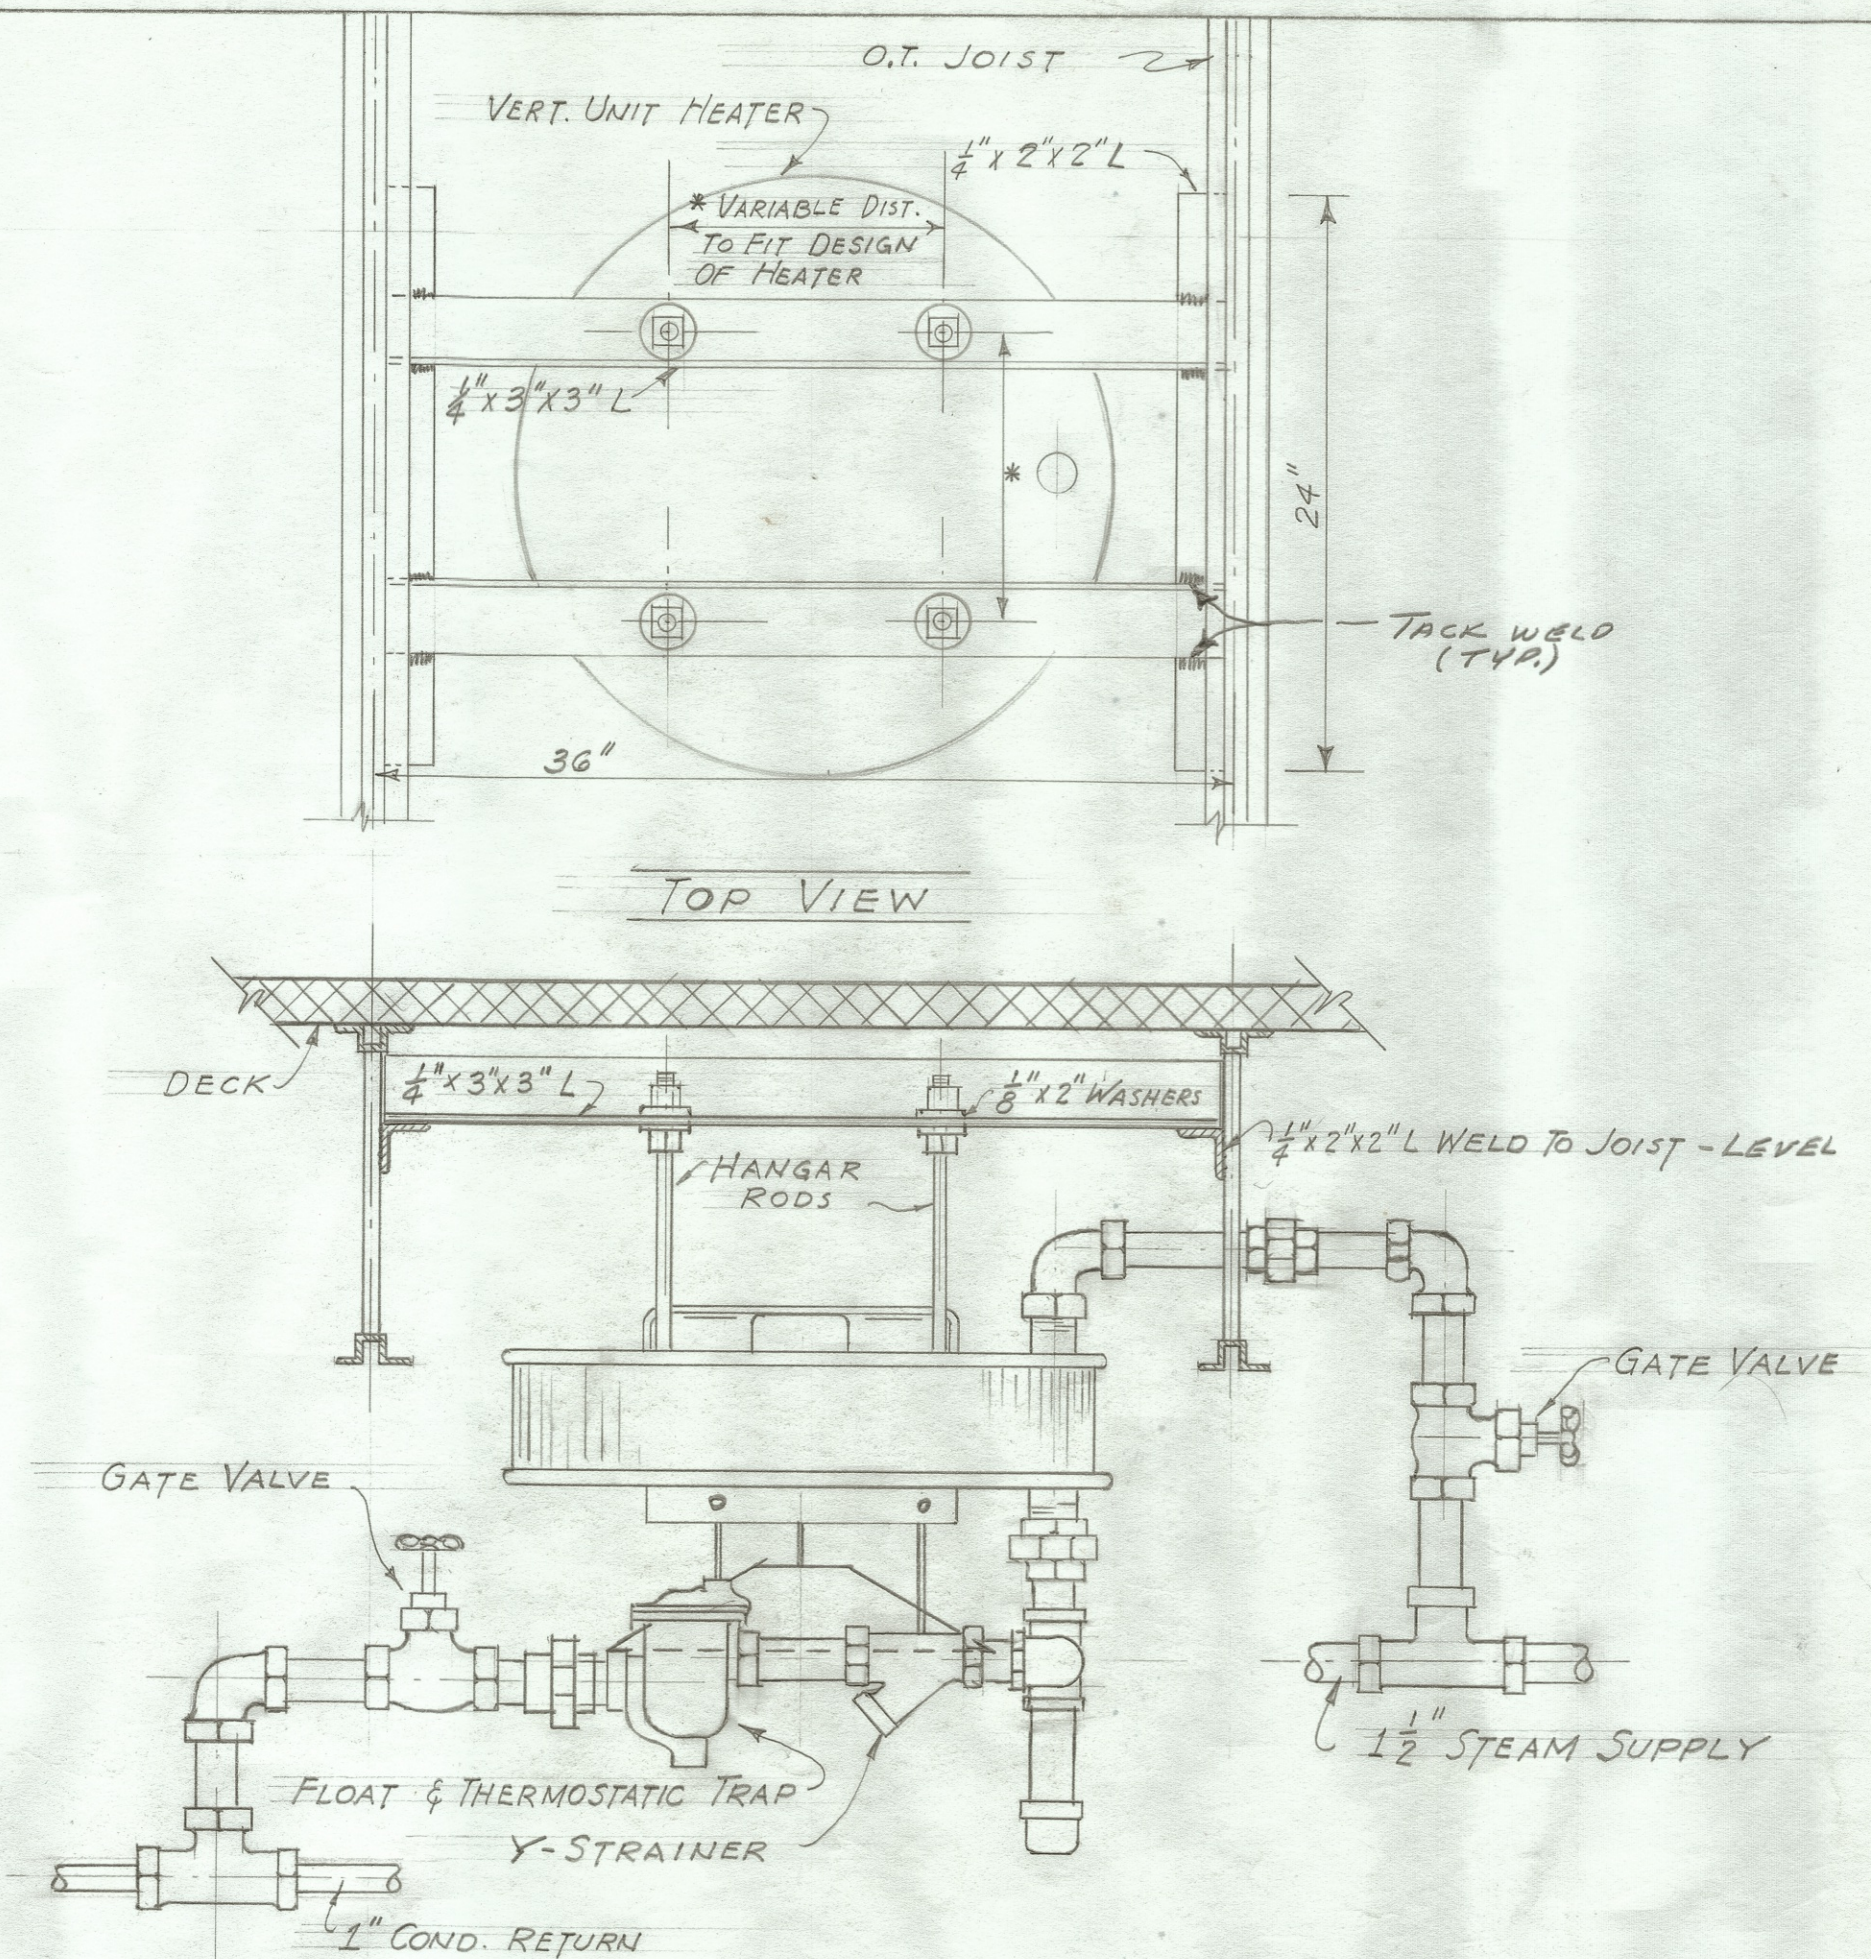

ELEVATION

UNIT HEATERS-HANGAR & PIPING DETAILS

SCALE: $\frac{1}{2}'' = 1'-0''$

ROOF FRAMING; HEATING & VENTILATING ADDITION TO LAUNDRY MASSILLON STATE HOSPITAL - MASSILLON, O.

APPROVED _____ 19__	PREPARED FOR STATE OF OHIO DEPARTMENT OF PUBLIC WORKS		
DIRECTOR-MENT. HYG. & CORR.	PREPARED BY DEPARTMENT OF MENTAL HYGIENE AND CORRECTION		
APPROVED _____ 19__			
CONSULTING ARCHITECT			
APPROVED _____ 19__			
DIRECTOR OF PUBLIC WORKS			
ENGINEER	DRAWN <u>VW Meyers</u> DATE <u>5/1/67</u>	DRAWING NO. <u>C-1645-E</u>	
SECTION CHIEF	CHECKED _____ DATE _____	SHEET <u>5</u> OF <u>7</u>	
	SCALE <u>NOTED</u>		